

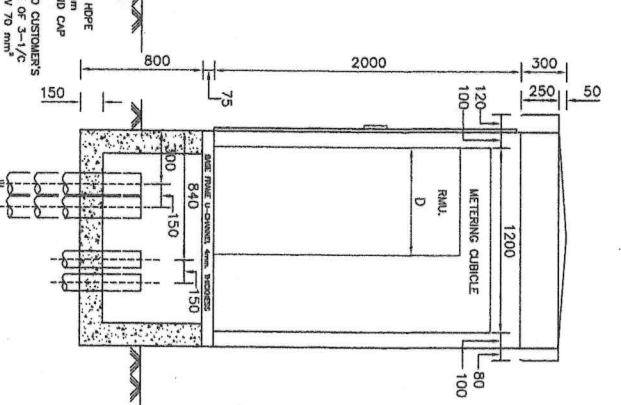
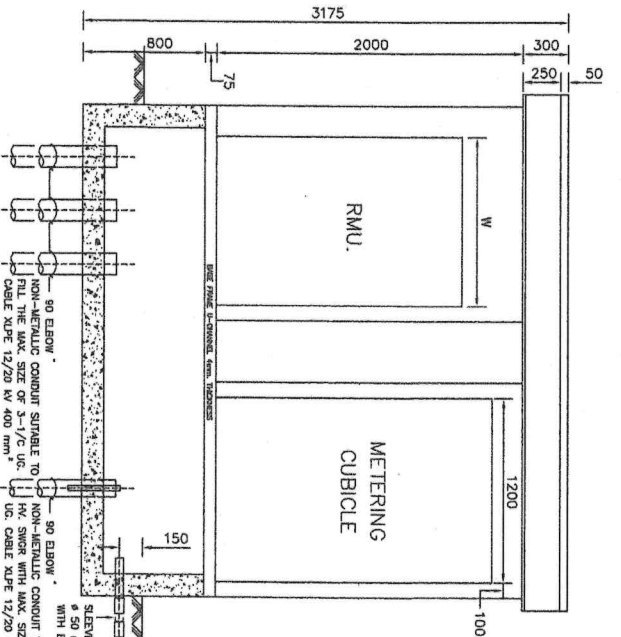


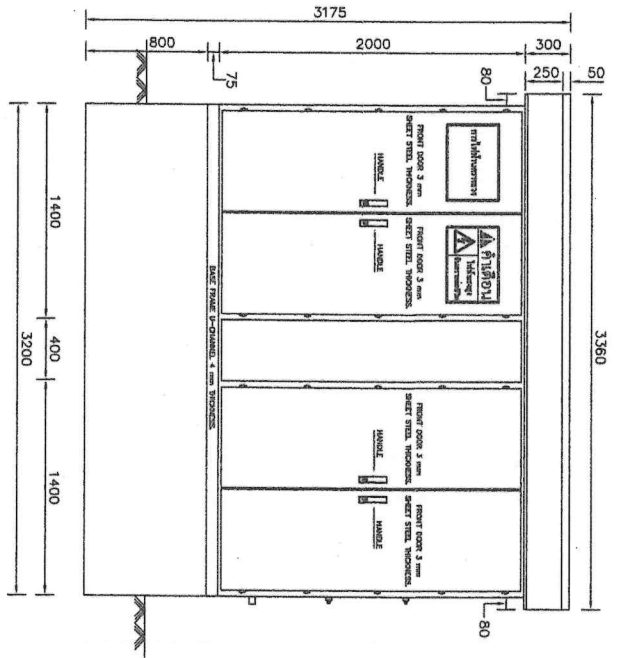


FRONT VIEW

SIDE VIEW

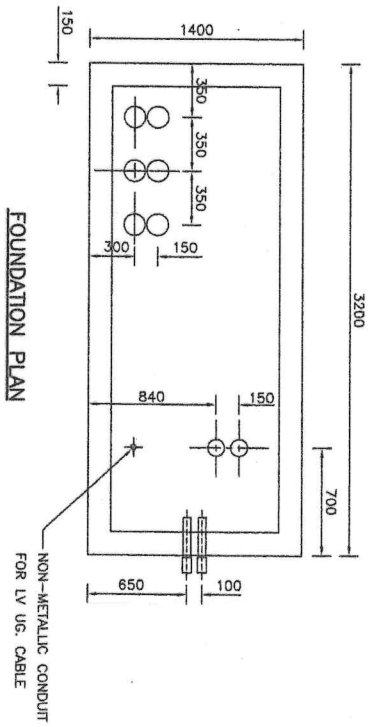



FOUNDATION PLAN

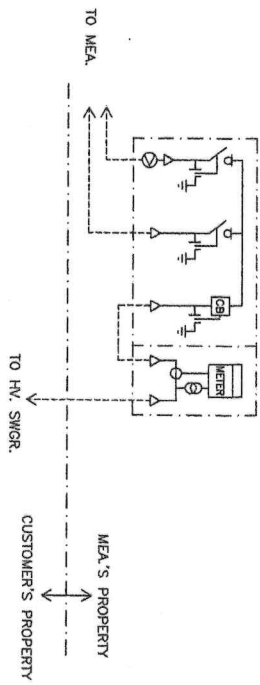




SINGLE LINE DIAGRAM

REV. NO.	DESCRIPTION	OF	REVISIONS	BY	DATE
DR. <i>Ground</i>	ENGR. <i>Ground</i>				
CHK.					
DIR. DIV.					
DATE					
METROPOLITAN ELECTRICITY AUTHORITY POWER SYSTEM PLANNING DEPARTMENT 12 & 24 kV OUTDOOR ENCLOSURE FOR RING MAIN UNIT WITH METERING CUBICLE TYPE II					
SCALE	NONE				
SUPERSEEDING					
SH. NO.	1	OF	2		
DWG. NO.	060615				


Don't forget

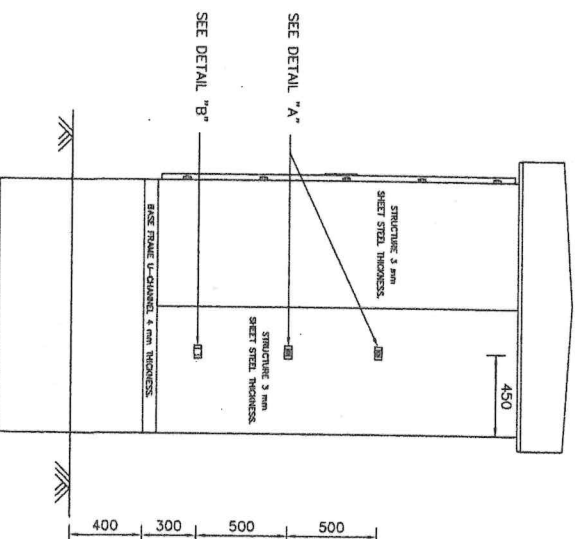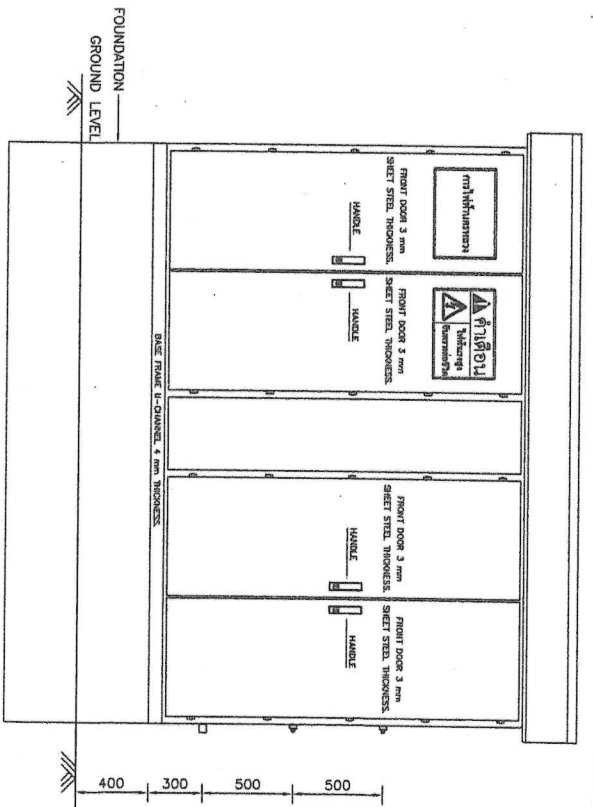

POSITIONS OF METER BOX HANGER AND CONDUIT SUPPORT

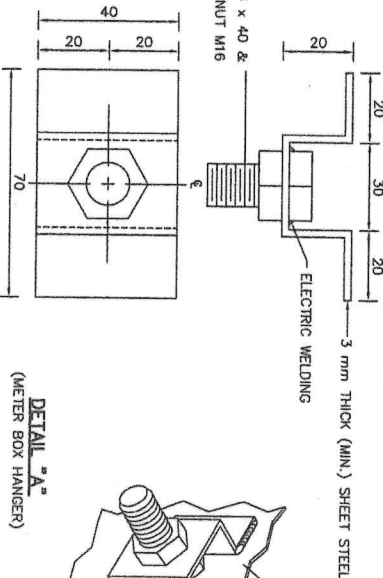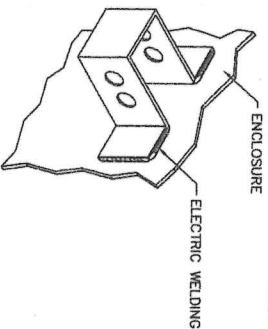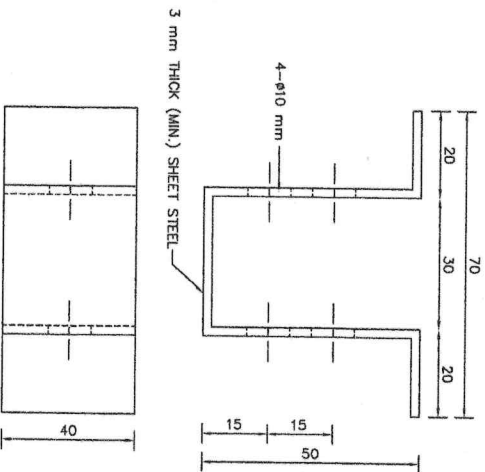

DETAIL "A"
(METER BOX HANGER)




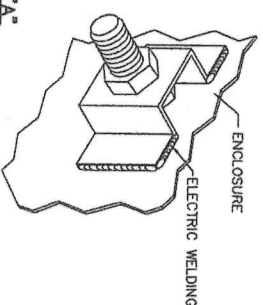


DETAIL "B"
(CONDUIT SUPPORT)


NOTE: DIMENSIONS ARE IN mm UNLESS OTHERWISE SPECIFIED.

REV. NO.	DESCRIPTION	OF	REVISIONS	BY	DATE
DR. <i>Ground</i> ENGR. <i>Ground</i>	METROPOLITAN ELECTRICITY AUTHORITY				
CH.F. SEC.	POWER SYSTEM PLANNING DEPARTMENT				
CHK.	12 & 24 kV OUTDOOR ENCLOSURE				
DIR. DIV.	FOR RING MAIN UNIT				
DATE	WITH METERING CUBICLE TYPE II				
SCALE	NONE				
SUPERSEDED	SH. NO. 2 OF 2				
DWG. NO.	060615				


John H. ...

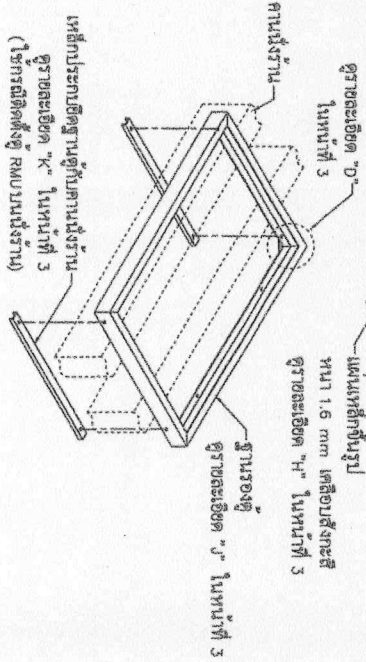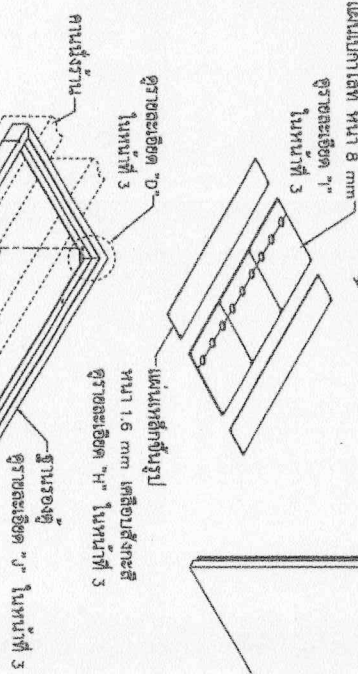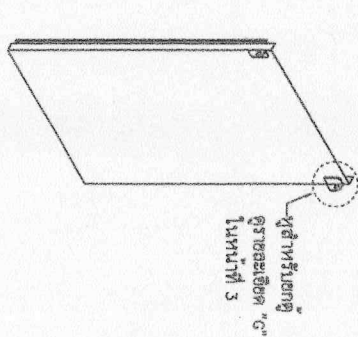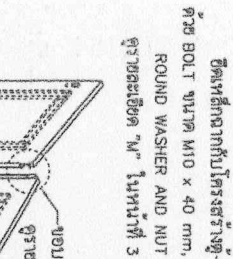


Demo

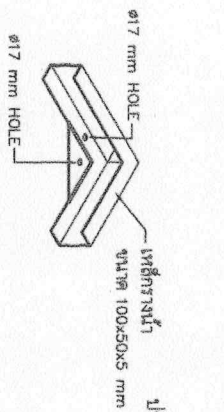


รายละเอียด "D"

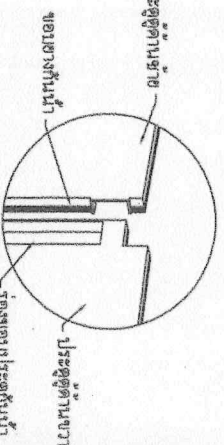


รายละเอียด "E"

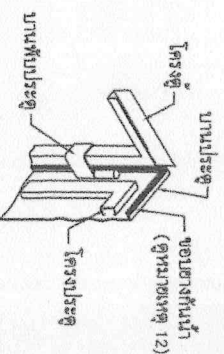


รายละเอียด "F"

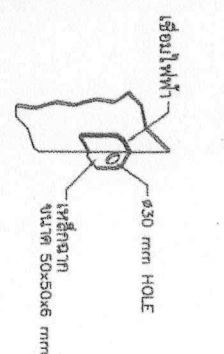


รายละเอียด "G"

 


รายละเอียด "H"

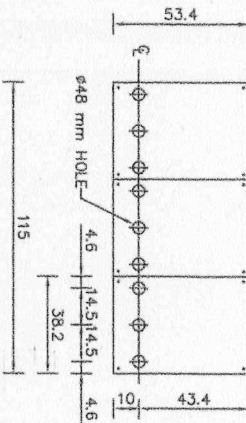


รายละเอียด "I"

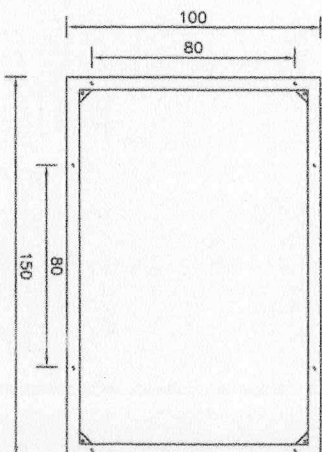


รายละเอียด "J"

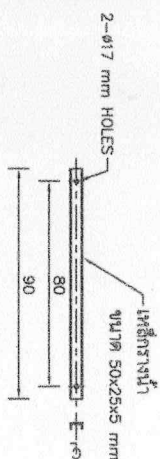

รายละเอียด "K"

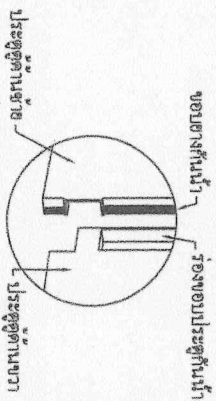

รายละเอียด "L"

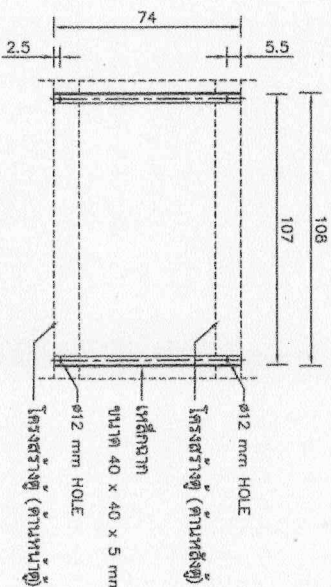

รายละเอียด "M"

REV. NO.	DESCRIPTION	OF	REVISIONS	BY	DATE
----------	-------------	----	-----------	----	------


METROPOLITAN ELECTRICITY AUTHORITY POWER SYSTEM PLANNING DEPARTMENT

DR. <i>Shangchai ENGR. Moolad</i>	SCALE	NONE
CH. ENGR. <i>Wongthai</i>	SUPERSEDING DATE	31/9/2561
DEP. DIV. <i>Piyachai</i>	SH. NO.	3 OF 3
DIR. DIV. <i>Pakthai</i>	DATE	8/8/2565


แบบร่างชุด อุปกรณ์ทั้งหมดในแผ่นที่ 1

2

Signature

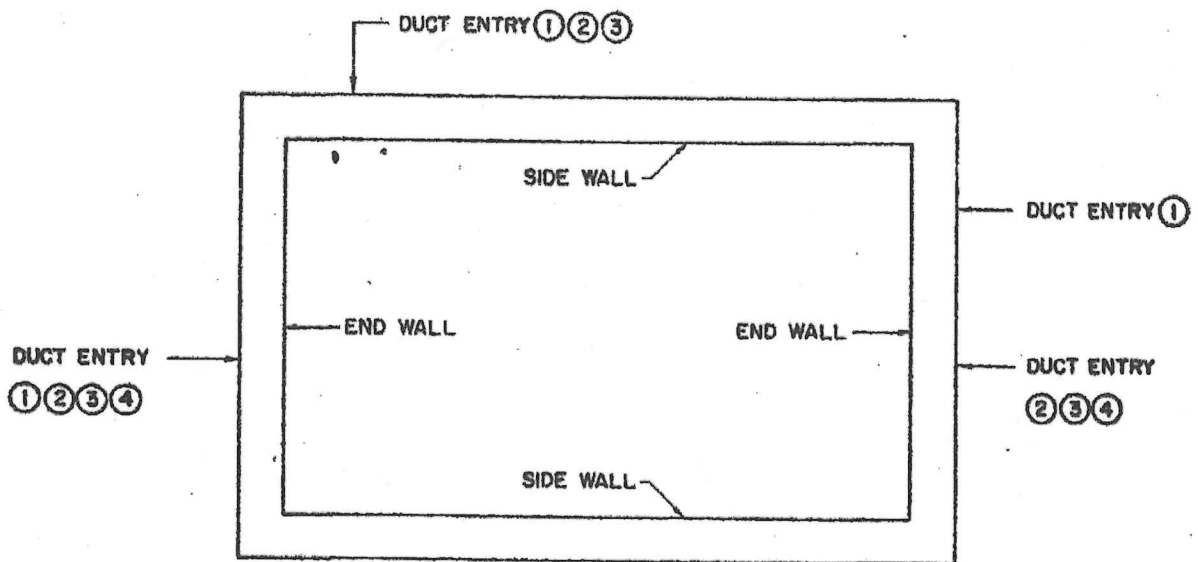

PLAN

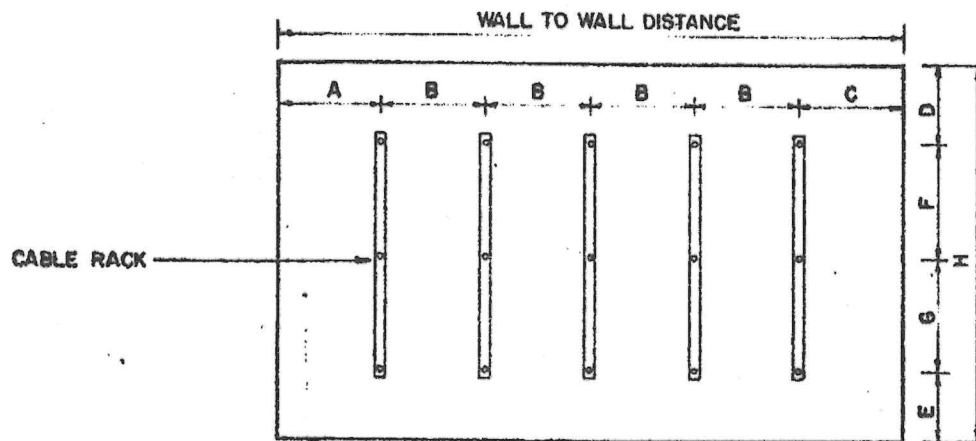


SIDE WALL TYPE I
(NO DUCT ENTRY)


NOTES

- ① = DUCT ENTRY FOR MANHOLE TYPE A-1 & A-1/1 & A-1/2
- ② = " " " " A-2 & A-2/1
- ③ = " " " " A-3 & A-3/1
- ④ = " " " " A-4 & A-4/1 & A-4/2


REV. NO.	DESCRIPTION OF REVISIONS				BY	DATE
DR. <i>[Signature]</i>	CHK. <i>Sombath</i>	METROPOLITAN ELECTRICITY AUTHORITY			SCALE NONE	
DIV. CHIEF <i>Suchart B.</i>		CABLE RACK MOUNTING LOCATIONS FOR MANHOLE TYPE A-1, A-1/1, A-1/2, A-2, A-2/1, A-3, A-3/1, A-4/1, A-4/2			SUPERSEDING 2413	
EXC. MGR. <i>T.H.</i>					SH. NO. 1 OF 5	
QTY. GEN. MGR. <i>Bongvut</i>					DWG. NO. UG-2-100	
DATE 31/3/2530						

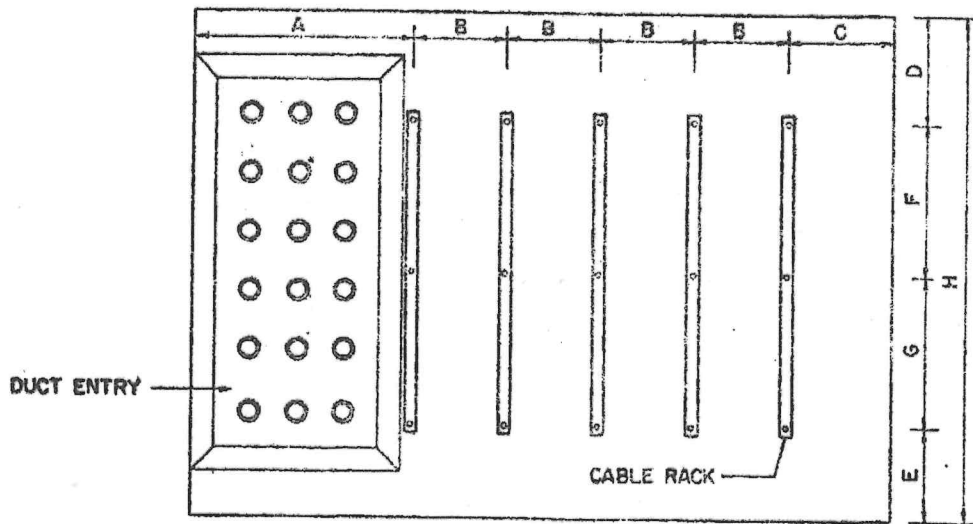

SIDE WALL TYPE 2
(DUCT ENTRY NEAR CORNER)

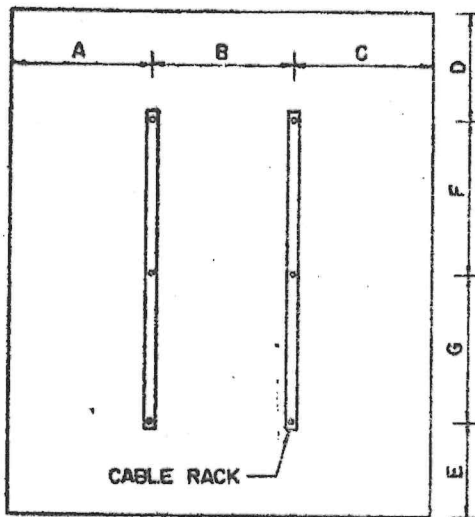


END WALL TYPE 1
(NO DUCT ENTRY)

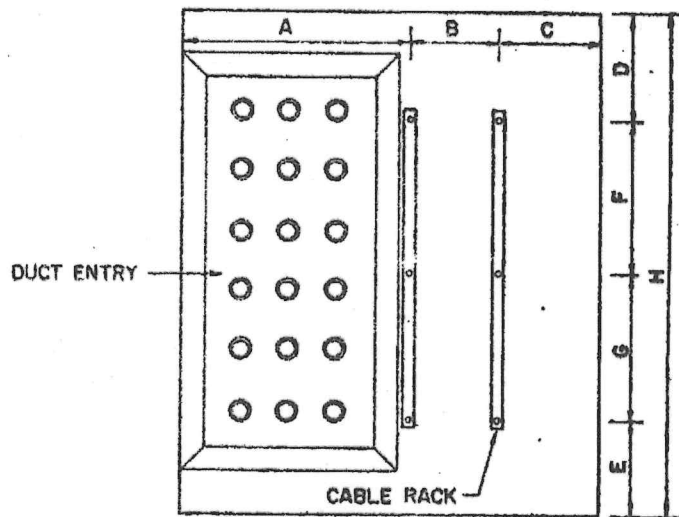


END WALL TYPE 2
(DUCT ENTRY NEAR CORNER)

REV. NO.	DESCRIPTION	OF	REVISIONS	BY	DATE.
DR. <i>ch</i>	CHK. <i>Sombat</i>		METROPOLITAN ELECTRICITY AUTHORITY		
DIV. CHIEF. <i>Suchart P.</i>	CABLE RACK MOUNTING LOCATIONS FOR MANHOLE TYPE			SCALE	NONE
EXC. MGR. T.H.				SUPERSEDING	2413
DTY. GEN. MGR. <i>Bongwira</i>				SH. NO.	2 OF 5
DATE 31/3/2530				DWG. NO.	UG-2-100
A-1, A-1/1, A-1/2, A-2, A-2/1, A-3, A-3/1, A-4/1, A-4/2					

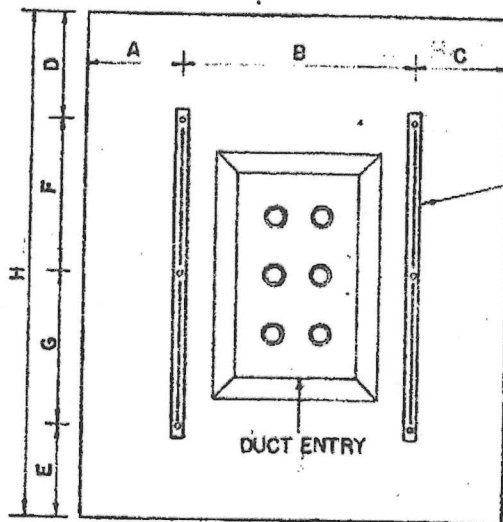

END WALL TYPE 3
(CENTER DUCT ENTRY)

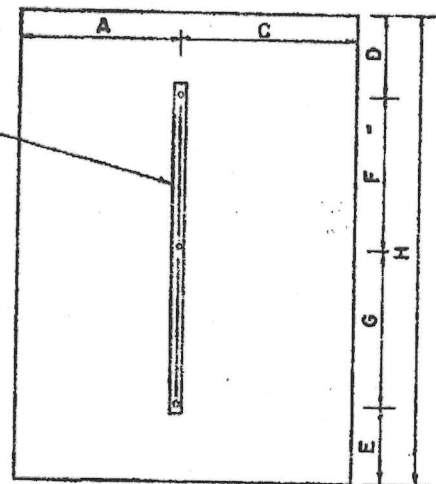

END WALL TYPE 4
(NO DUCT ENTRY)

[Handwritten signature]

[Handwritten mark]

REV. NO.	DESCRIPTION OF REVISIONS				BY	DATE
DR. <i>[Signature]</i>	CHK. <i>[Signature]</i>	METROPOLITAN ELECTRICITY AUTHORITY			SCALE	NONE
DIV. CHIEF <i>[Signature]</i>	CABLE RACK MOUNTING LOCATIONS FOR MANHOLE TYPE A-1, A-1/1, A-1/2, A-2, A-2/1, A-3, A-3/1, A-4/1, A-4/2			SUPERSEDING 2413		
EXC. MGR. <i>[Signature]</i>				SH. NO. 3 OF 5		
DTY. GEN. MGR. <i>[Signature]</i>				DWG. NO. UG-2-100		
DATE 31/3/2530						

TABLE A
FOR RACKING SINGLE CONDUCTOR CABLES

CABLE RACK LOCATION (DIMENSIONS ARE IN CM.)											
MANHOLE TYPES	SIDE WALL LOCATION										
	SIDE WALL TYPES	NUMBER OF CABLE RACK POSITIONS	DIMENSIONS								REMARKS
			A	B	C	D	E	F	G	H	
A-1	1	5	90	45	90	45	40	65	65	215	
	2	5	95	45	85	45	40	65	65	215	
A-1/1	1	5	90	45	90	45	40	65	65	215	
A-1/2	2	5	95	45	85	45	40	65	65	215	
A-2	1	5	70	45	70	35	35	65	65	200	
	2	4	95	45	90	35	35	65	65	200	
A-2/1	1	5	70	45	70	35	35	65	65	200	
	2	4	95	45	90	35	35	65	65	200	
A-3	1	2	90	95	90	25	30	65	65	185	
	2	2	95	90	90	25	30	65	65	185	
A-3/1	1	2	90	95	90	25	30	65	65	185	
	2	2	95	90	90	25	30	65	65	185	
A-4/1	1	7	70	45	70	45	40	65	65	215	
A-4/2	2	6	95	45	90	45	40	65	65	215	

Am Hossain


REV. NO.	DESCRIPTION OF REVISIONS	BY	DATE
DR. <i>Am Hossain</i>	CHK. <i>Saiman</i>		
METROPOLITAN ELECTRICITY AUTHORITY		SCALE	
CABLE RACK MOUNTING LOCATIONS FOR MANHOLE TYPE		SUPERSEDING 2413	
A-1, A-1/1, A-1/2, A-2, A-2/1, A-3, A-3/1, A-4/1, A-4/2		SH. NO. 4 OF 5	
DATE 31/3/2530		DWG. NC UG-2-100	

Am Hossain

TABLE B
FOR RACKING SINGLE CONDUCTOR CABLES

CABLE RACK LOCATION (DIMENSIONS ARE IN CM.)											
MANHOLE TYPES	END WALL LOCATION										REMARKS
	END WALL TYPES	NUMBER OF CABLE RACK POSITIONS	DIMENSIONS								
			A	B	C	D	E	F	G	H	
A - 1	1	2	60	60	60	45	40	65	65	215	
	2	2	95	40	45	45	40	65	65	215	
	3	2	40	100	40	45	40	65	65	215	
	4	-	-	-	-	-	-	-	-	-	
A - 1/1 A - 1/2	1	2	60	60	60	45	40	65	65	215	
	2	2	95	40	45	45	40	65	65	215	
	3	2	40	100	40	45	40	65	65	215	
	4	-	-	-	-	-	-	-	-	-	
A - 2	1	-	-	-	-	-	-	-	-	-	
	2	1	95	0	55	35	35	65	65	200	
	3	2	35	80	35	35	35	65	65	200	
	4	1	75	0	75	35	35	65	65	200	
A - 2/1	1	-	-	-	-	-	-	-	-	-	
	2	1	95	0	55	35	35	65	65	200	
	3	2	35	80	35	35	35	65	65	200	
	4	1	75	0	75	35	35	65	65	200	
A - 3	1	-	-	-	-	-	-	-	-	-	
	2	1	95	0	55	25	30	65	65	185	
	3	2	35	80	35	25	30	65	65	185	
	4	1	75	0	75	25	30	65	65	185	
A - 3/1	1	-	-	-	-	-	-	-	-	-	
	2	1	95	0	55	25	30	65	65	185	
	3	2	35	80	35	25	30	65	65	185	
	4	1	75	0	75	25	30	65	65	185	
A - 4/1 A - 4/2	1	2	60	60	60	45	40	65	65	215	
	2	2	95	40	45	45	40	65	65	215	
	3	2	40	100	40	45	40	65	65	215	
	4	-	-	-	-	-	-	-	-	-	


REV. NO.	DESCRIPTION OF REVISIONS				BY	DATE
DR. <i>dk</i>	METROPOLITAN ELECTRICITY AUTHORITY				SCALE	
DIV. CHIEF <i>Suchart B.</i>	CABLE RACK MOUNTING LOCATIONS FOR MANHOLE TYPE A-1, A-1/1, A-1/2, A-2, A-2/1, A-3, A-3/1, A-4/1, A-4/2				SUPERSEDING 2413	
EXC. MGR. <i>T.H.</i>					SH. NO. 5 OF 5	
DTY. GEN. MGR. <i>Rog</i>					DWG NO. UG-2-100	
DATE 31/3/2530						

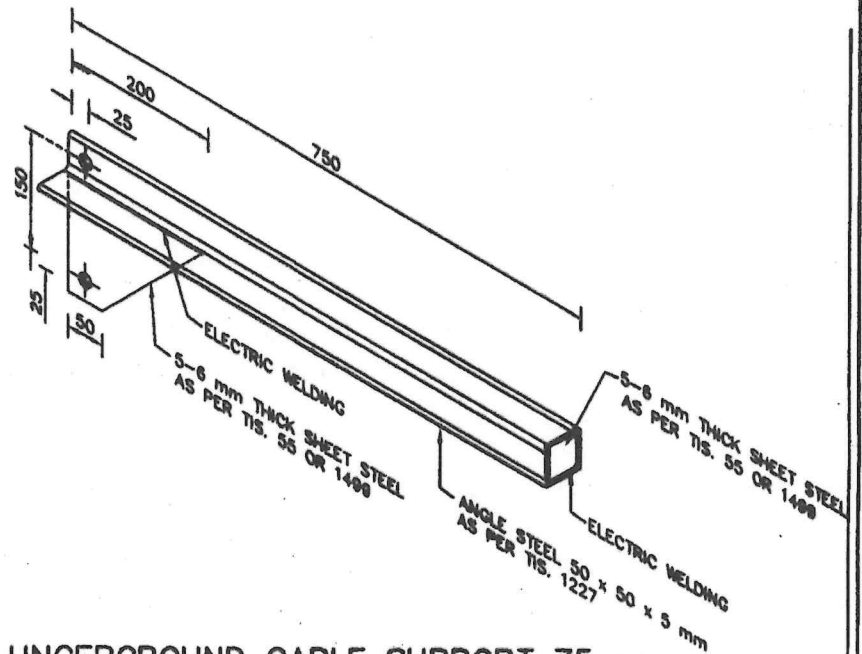

UNDERGROUND CABLE SUPPORT 75 cm
(CODE NO. 6145-268-02000)


NOTES

1. DIMENSIONS ARE IN mm
2. ALL HOLES SHALL BE $\phi 18$ mm
3. AFTER FABRICATION, THE CABLE RACK SUPPORT SHALL BE GALVANIZED BY HOT-DIP PROCESS. THE MINIMUM AVERAGE THICKNESS OF ZINC-COATING AS PER ASTM A123/123M.

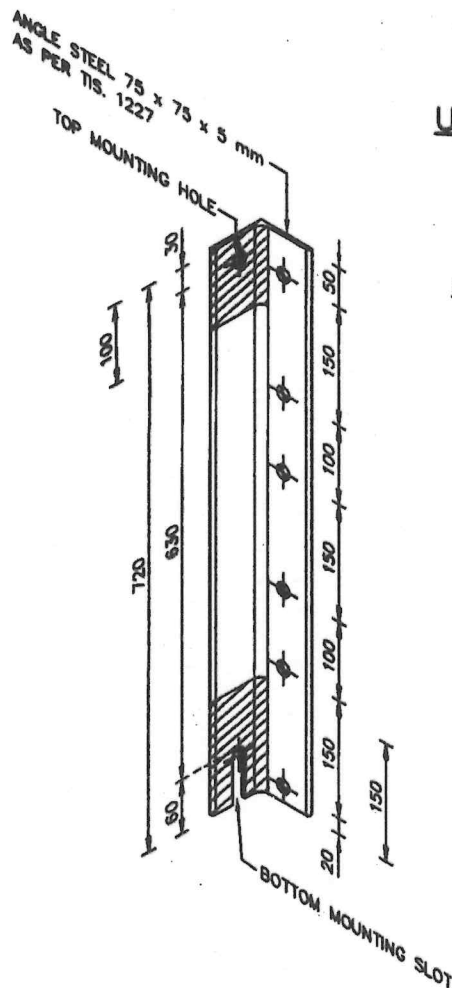

UNDERGROUND CABLE RACK 72 cm
(CODE NO. 6145-268-01500)

1	REVISED DRAWING & TITLE			Pongsan	23/1/52
REV.NO.	DESCRIPTION OF REVISIONS			BY	DATE
DR. Pannchai	CHK. Pongsan	METROPOLITAN ELECTRICITY AUTHORITY			SCALE NONE
DIR.DIV. R. Th	CABLE RACK SUPPORT FOR SUPPORTING UG CABLE			SUPERSEDING 10A4-0526	
DIR.DEPT. L. Th				SH.NO. 1 OF 1	
DEP.GOV. L. Th				DWG. NO. UG-8-014	
DATE 6/6/2551					

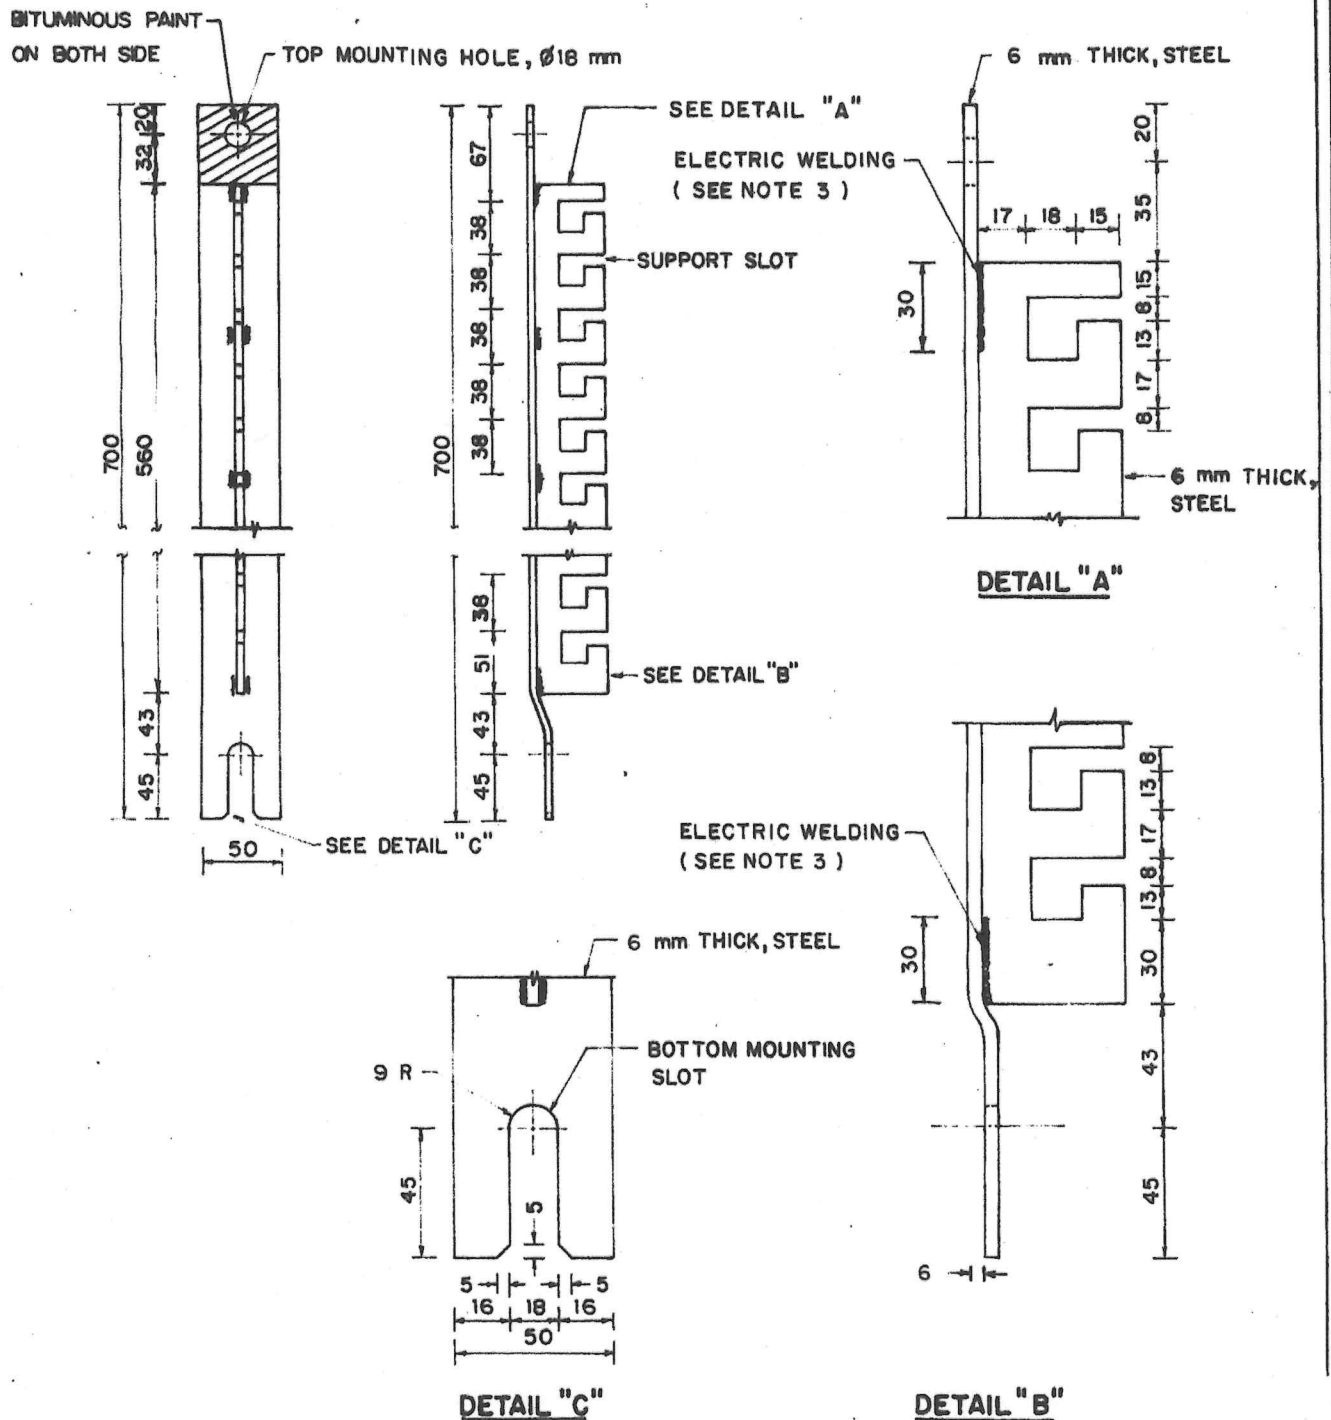


14-HOLE UG. CABLE RACK (CODE NO. 6145-268-014000)

NOTES


1. DIMENSIONS ARE IN mm.
2. MATERIAL SHALL BE GALVANIZED BY HOT-DIP PROCESS AFTER FABRICATION.
THE MINIMUM AVERAGE THICKNESS OF ZINC-COATING AS PER ASTM A123/123M.
3. ELECTRIC WELDING SHALL BE MADE ON BOTH SIDES AT APPROX. 10 CM. INTERVALS.

2	ADDED BITUMINOUS PAINT AROUND TOP MOUNTING HOLE AND REVISED DIMENSIONS, CODE NO. 8 & NOTE 2		Phngan	23/1/52
1	REVISED STEEL THICKNESS AND DRAWING		Sombat.	11/1/33
REV. NO.	DESCRIPTION OF REVISIONS			BY DATE
DR. <i>[Signature]</i>	CHK. <i>Sombat.</i>	METROPOLITAN ELECTRICITY AUTHORITY		SCALE NONE
DIV. CHIEF <i>Suehart B.</i>	UNDERGROUND CABLE RACK			SUPERSEDING
EXC. MGR. <i>T.H.</i>				SH. NO. 1 OF 1
DTY. GEN. MGR. <i>Bongrid</i>				DWG
DATE 14/5/2530				NO. UG-8-011


[Handwritten signatures and initials]

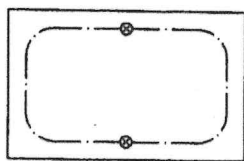


MANHOLE TYPE A

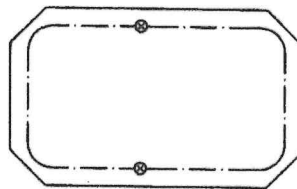

MANHOLE TYPE B

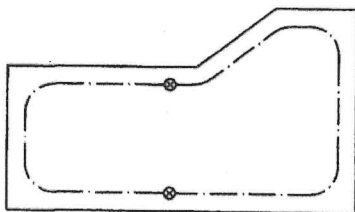

MANHOLE TYPE L

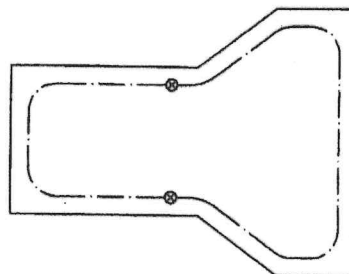

MANHOLE TYPE T

⊗ = GROUND ROD COPPER-CLAD $\phi 5/8"$ x 8 ft


----- = GROUND LOOP, CONDUCTOR SIZE : 35 mm² (CU) PVC INSULATED FOR ONLY 12 OR 24 kV CABLE JOINTS IN MANHOLE
 : 95 mm² (CU) PVC INSULATED FOR ONLY 69 OR 115 kV CABLE JOINTS IN MANHOLE
 : 95 mm² (CU) PVC INSULATED FOR MIXED 69 OR 115 kV AND 12 OR 24 kV CABLE JOINTS IN MANHOLE

GROUND LOOP IN VARIOUS TYPE OF MANHOLES


NOTE GROUND LOOP IN HANHOLE IS NOT REQUIRED.

REV.NO.	DESCRIPTION OF REVISIONS			BY	DATE
DR. <i>Pornchai</i>	CHK. <i>Pongsan</i>	METROPOLITAN ELECTRICITY AUTHORITY			SCALE NONE
DIR.DIV. <i>Chudhant</i>	GROUND LOOP IN MANHOLE			SUPERSEDING UG-2-200 SH.NO.1	
DIR.DEPT. <i>Witachai</i>				SH.NO. 1 OF 1	
DEP.GOV. <i>Witachai</i>				DWG. NO. UG-10-005	
DATE 9/9/2551					


Dr. Pongsan

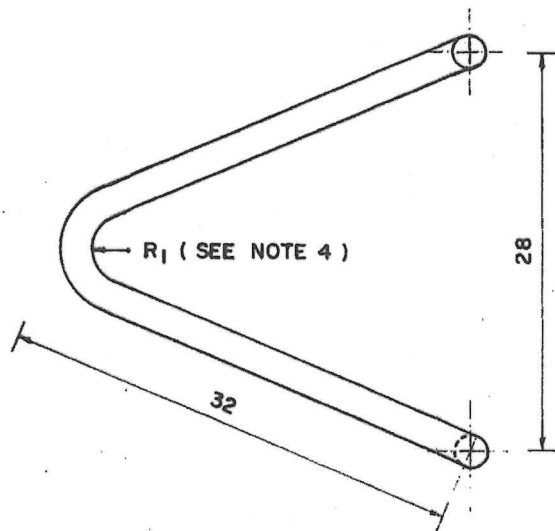


TOP VIEW

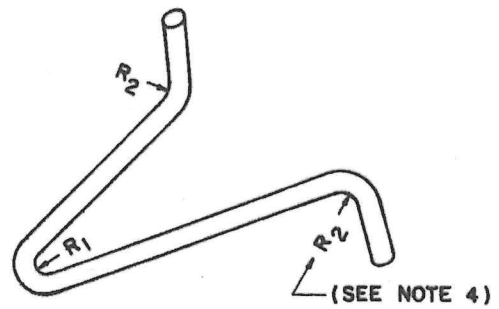

ISOMETRIC VIEW

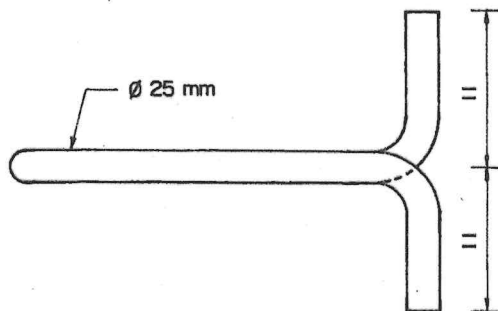

FRONT VIEW

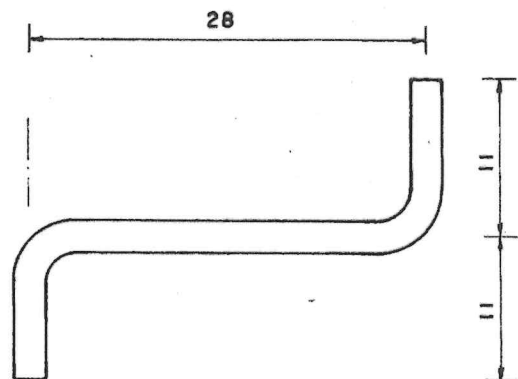

SIDE VIEW

PULLING IRON


(CODE NO. 5615-044-81200)

NOTES.

1. DIMENSIONS ARE IN cm UNLESS OTHERWISE SPECIFIED.
2. MATERIAL: Ø25 mm STEEL ROUND BAR. (SR. 24, TIS. 20)
3. PULLING IRON SHALL BE HOT-DIP GALVANIZED AFTER FORMING.
THE MINIMUM AVERAGE OF ZINC-COATING AS PER ASTM A123/123M.
4. THE BENDING RADIUS SHALL BE AS FOLLOWS:
 $R_1 = 30 \pm 5$ mm
 $R_2 = 22 \pm 1$ mm
5. MINIMUM RESISTING PULLING TENSION OF THE PULLING IRON
SHALL NOT BE LESS THAN 3000 kg.

1	CHANGED SIZE OF STEEL ROUND BAR FROM Ø22 mm TO Ø25 mm AND REVISED NOTES			Pongsan	23/1/52
REV. NO.	DESCRIPTION OF REVISIONS			BY	DATE
DR. Apichart	CHK. Sankar	METROPOLITAN ELECTRICITY AUTHORITY			SCALE NONE
DIV. CHIEF Sanchai B.	PULLING IRON FOR MANHOLE AND HANDHOLE			SUPERSEDING 2901	
EXC. MGR. T.H.				SH. NO. 1 OF 1	
DTY. GEN. MGR. Pongsan				DWG NO. UG-8-012	
DATE 14/5/2530					

Handwritten signatures and initials at the bottom right of the page.

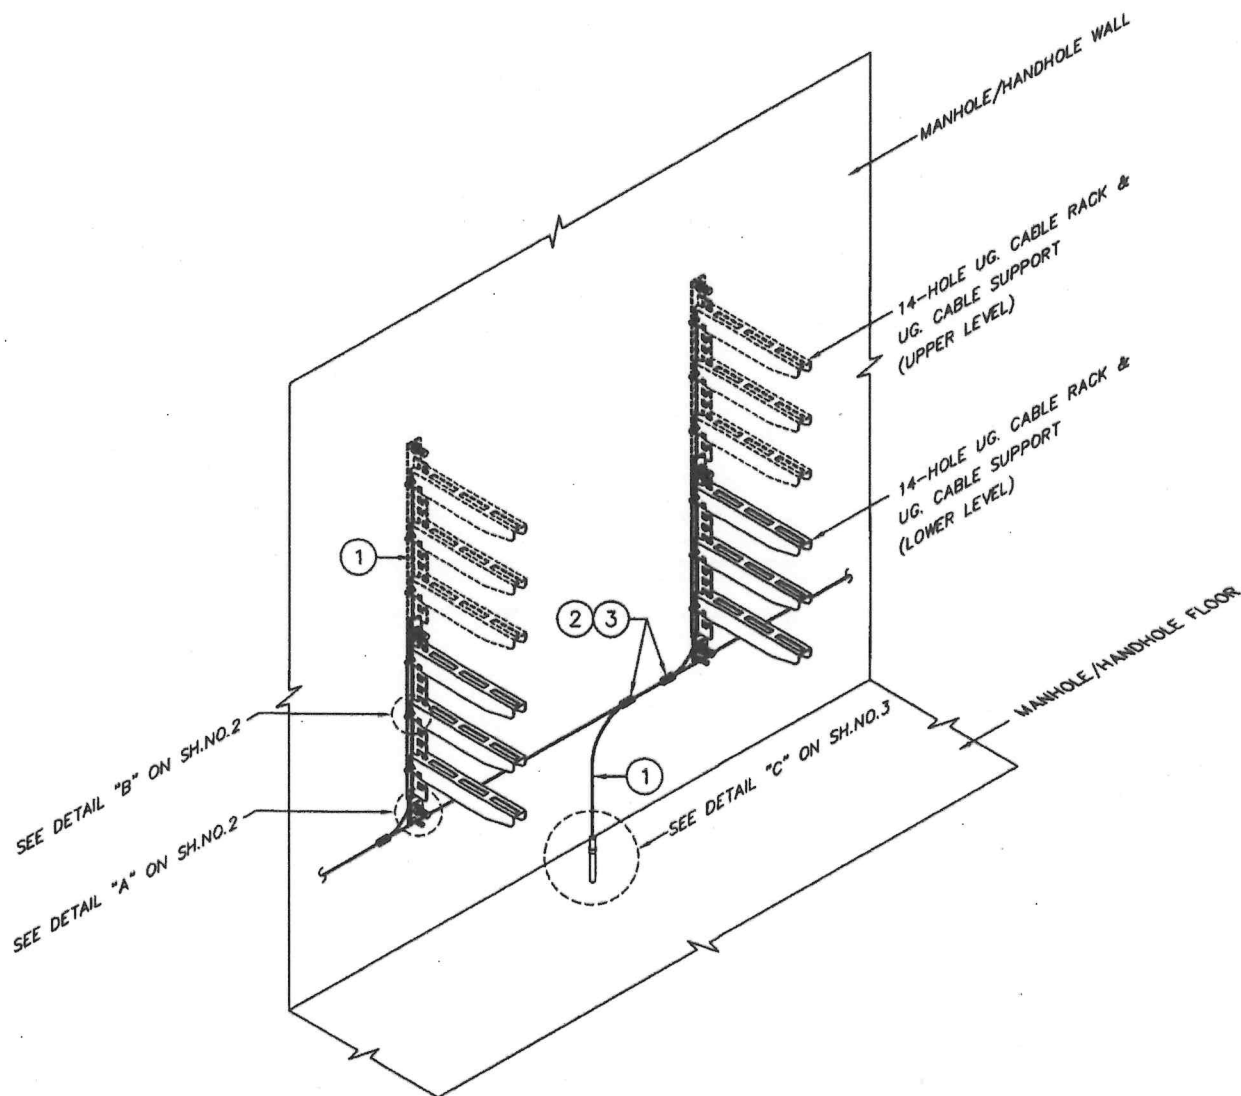


GROUNDING PRACTICE FOR CABLE RACKS IN 12/24 kV MANHOLE/HANDHOLE

NOTE


THE DRAWING DOES NOT ILLUSTRATE GROUNDING DETAILS FOR SPLICED CABLE. IF THERE ARE UG. CABLE SPLICES IN MANHOLE, SEE MORE GROUNDING PRACTICE IN DWG.NO. UG-10-006

REV.NO.	DESCRIPTION OF REVISIONS		BY	DATE
DR. Monthol	CHK. Pongsan	METROPOLITAN ELECTRICITY AUTHORITY	SCALE	NONE
DIR.DIV. Chuchart		GROUNDING PRACTICE FOR CABLE RACK IN 12/24 kV MANHOLE/HANDHOLE	SUPERSEDING	
DIR.DEPT. Jirochai			SH.NO. 1 OF 3	
DEP.GOV. <i>[Signature]</i>			DWG. NO.	UG-10-007
DATE 9/9/2551				


[Handwritten signatures and initials]

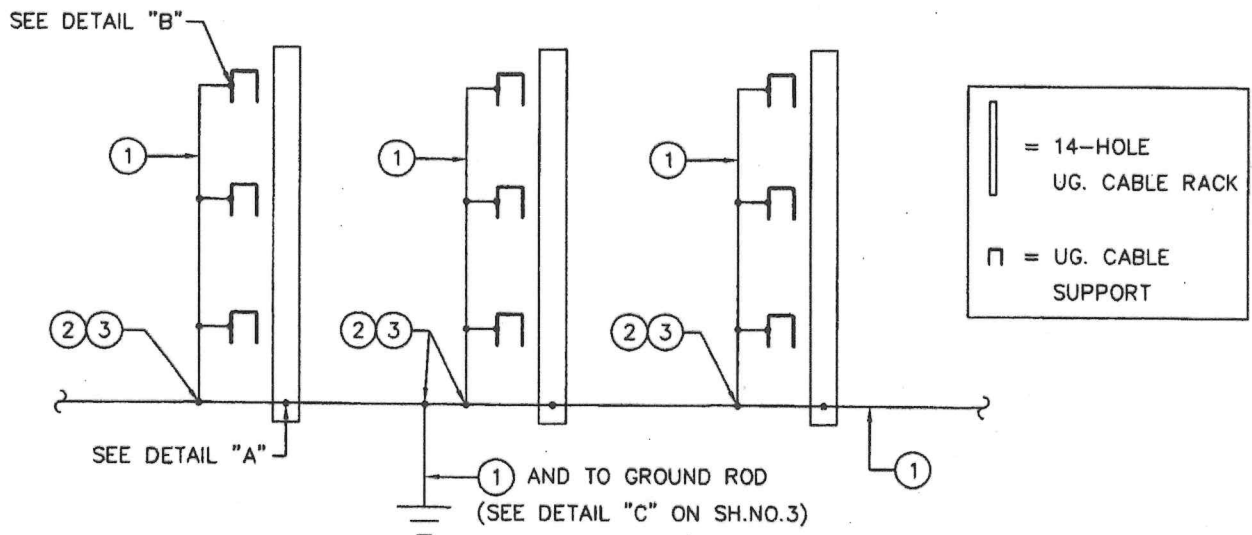

GROUNDING DIAGRAM

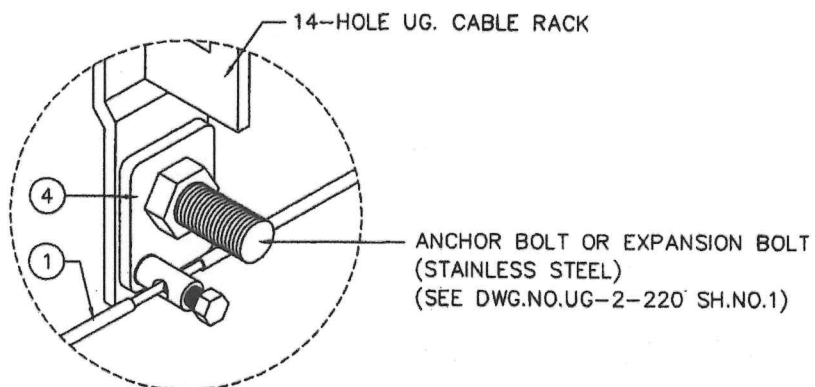


DETAIL "A"
(STEEL GROUND TERMINAL ASSEMBLY)

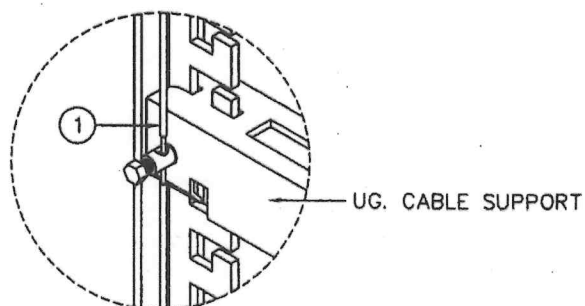

DETAIL "B"
(GROUND TERMINAL OF UG. CABLE SUPPORT)

REV.NO.	DESCRIPTION OF REVISIONS		BY	DATE
DR. Monthol	CHK. Pongsan	METROPOLITAN ELECTRICITY AUTHORITY GROUNDING PRACTICE FOR CABLE RACK IN 12/24 kV MANHOLE/HANDHOLE	SCALE	NONE
DIR.DIV. Chuchart			SUPERSEDING	
DIR.DEPT. Jursachai			SH.NO. 2 OF 3	
DEP.GOV. [Signature]			DWG. NO.	UG-10-007
DATE 9/9/2551				


[Handwritten signatures and initials]

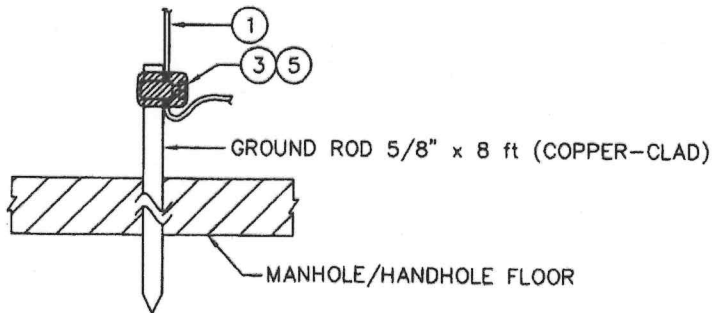

DETAIL "C"
(CONNECTION TO GROUND ROD)

BILL OF MATERIAL			
ITEM NO.	CODE NO.	REQ'D	DESCRIPTION
1	6145-201-01600	AS REQ'D	GROUND WIRE, CU COND. PVC INSULATED MEA TYPE A 16 mm ²
2	6145-063-60100		CONNECTOR, COMPRESSION TYPE(CU), C-FRAME 10-16 mm ² R & 16 mm ² T
3	5970-316-62900		EPR TAPE 3/4" x 30 ft
4	6145-123-00200		STEEL GROUND TERMINAL 45 x 60 x 6 mm
5	6145-092-15300		CLAMP, GROUND ROD 5/8" FOR 16-35 mm ² GROUND WIRE

REV.NO.	DESCRIPTION OF REVISIONS		BY	DATE
DR. Monthol	CHK. Pongsan	METROPOLITAN ELECTRICITY AUTHORITY GROUNDING PRACTICE FOR CABLE RACK IN 12/24 kV MANHOLE/HANDHOLE	SCALE	NONE
DIR.DIV. Chuchart			SUPERSEDING	
DIR.DEPT. Lurachai			SH.NO.	3 OF 3
DEP.GOV. Iga			DWG.	
DATE 9/9/2551			NO.	UG-10-007

 24



ALLOWABLE AMPACITIES IN AMPERES
FOR CABLE RATED $U_0/U = 12/20$ kV IN DUCT BANK (CONCRETE ENCASED)
INSTALLATION METHOD

AMBIENT EARTH TEMPERATURE = 30 °C


NATIVE SOIL THERMAL RESISTIVITY = 1.0 K·m/W (AVERAGE)

CONCRETE THERMAL RESISTIVITY = 1.0 K·m/W

DEPTH OF LAYING = 1.2 m (AVERAGE)

SHIELD BONDING : MULTIPLE-GROUNDED FOR CABLE SIZE UP TO 400 mm²
: SINGLE-POINT GROUNDED FOR CABLE SIZE 800 mm²

ARRANGEMENT IN CONDUIT : THREE CABLES IN COMMON DUCT FOR CABLE SIZE UP TO 400 mm²
: ONE CABLE IN ONE DUCT FOR CABLE SIZE 800 mm²

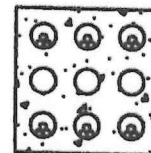

TYPICAL INSTALLATION

TABLE 4-310A CONDUCTOR SIZE UP TO 400 mm²

NOMINAL CROSS-SECTIONAL AREA OF CONDUCTOR, mm ²	NUMBER OF CIRCUITS								
	1-2			3-6			7-10		
	If=0.7	If=0.85	If=1.0	If=0.7	If=0.85	If=1.0	If=0.7	If=0.85	If=1.0
70	211	196	183	183	167	153	153	137	123
120	288	267	248	248	225	205	206	183	164
240	417	384	354	355	320	291	292	258	231
400	529	486	447	448	403	364	365	322	287


NOMINAL CROSS-SECTIONAL AREA OF CONDUCTOR, mm ²	NUMBER OF CIRCUITS								
	11-15			16-20			21-24		
	If=0.7	If=0.85	If=1.0	If=0.7	If=0.85	If=1.0	If=0.7	If=0.85	If=1.0
70	129	113	101	115	101	90	106	92	81
120	172	151	134	154	134	119	141	122	108
240	242	212	188	216	188	166	196	170	150
400	302	260	233	268	233	206	244	211	186

TABLE 4-310B CONDUCTOR SIZE 800 mm²


NOMINAL CROSS-SECTIONAL AREA OF CONDUCTOR, mm ²	3 ELECTRICAL DUCTS			6 ELECTRICAL DUCTS			9 ELECTRICAL DUCTS		
	If=0.7	If=0.85	If=1.0	If=0.7	If=0.85	If=1.0	If=0.7	If=0.85	If=1.0
800	1099	1013	936	934	841	763	826	735	660

NOTE SEE APPLICATION OF LOAD FACTOR (If) ON UG-4-100 SH.NO.2


REV.NO.	DESCRIPTION OF REVISIONS					BY	DATE
DR. <i>Manthol</i>	CHK. <i>Pongsan</i>	METROPOLITAN ELECTRICITY AUTHORITY				SCALE	NONE
DIR.DIV. <i>R Ph...</i>	POWER CABLE AMPACITIES CABLE LAID IN DUCT BANK (CONCRETE ENCASED) (SHIELDED EXTRUDED INSULATION CU CONDUCTOR, RATED 12/20 kV)				SUPERSEDING		
DIR.DEPT. <i>A. ...</i>					SH.NO.	1 OF 1	
DEP.GOV. <i>...</i>					DWG.	UG-4-310	
DATE 16/10/2548	NO.						

 


2 X 1 DUCT BANK

 


2 X 2 DUCT BANK

 


2 X 3 DUCT BANK

 


2 X 4 DUCT BANK

 


2 X 5 DUCT BANK

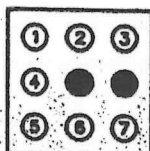


3 X 3 DUCT BANK

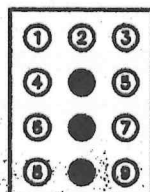


3 X 4 DUCT BANK

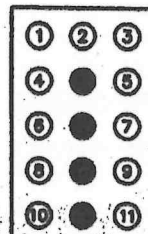


3 X 5 DUCT BANK

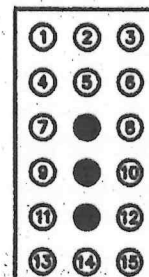


3 X 6 DUCT BANK

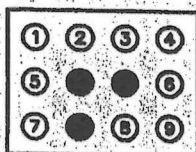


4 X 3 DUCT BANK

 


5 X 2 DUCT BANK

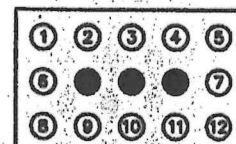

5 X 3 DUCT BANK

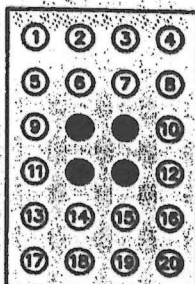

4 X 6 DUCT BANK

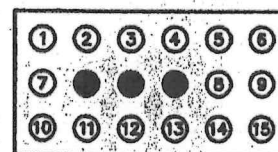

6 X 3 DUCT BANK

● - SPARE DUCT

CIRCUIT SEQUENCE

NOTES

1. CIRCUIT SEQUENCE SHOWN IN THIS DRAWING ARE UG. CABLE OF MULTI-CORE AND/OR SINGLE-CORE CABLE WITH A MAXIMUM SIZE OF 400 mm². THE SAID CONSTRUCTIONS REQUIRE 3 OR 4 CABLES PER CIRCUIT PER DUCT FOR SINGLE-CORE CABLE.
2. CIRCUIT SEQUENCES OF 69/115 kV UG. CABLE IN DUCT BANK ARE SPECIFIED ON SH.NO.2. THE SAID CONSTRUCTIONS REQUIRE 1 CABLE PER DUCT.

FOR CONSTRUCTION REFERENCE ONLY

REV.NO.	DESCRIPTION OF REVISIONS	BY	DATE
DR. Monthol	CHK. Pongsan		
DIR.DIV. R. Thant			
DIR.DEPT. A. Manwad			
DEP.GOV. Uga			
DATE 9/12/2546			

METROPOLITAN ELECTRICITY AUTHORITY


CIRCUIT SEQUENCE
OF
UG. CABLE IN DUCT BANK

SCALE NONE


SUPERSEDING UG-4-002
DATE 5/6/2534

SH.NO. 1 OF 2


DWG. NO. UG-4-002

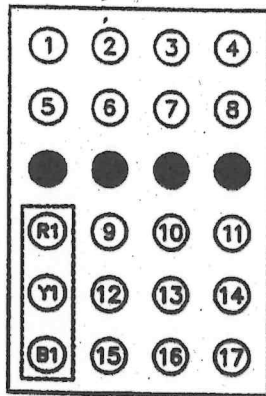


1-CKT SINGLE CONDUCTOR
OF TRANSMISSION LINE

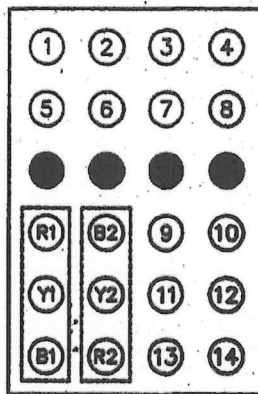


2-CKT SINGLE CONDUCTOR
OF TRANSMISSION LINE

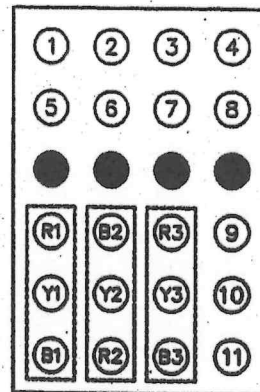


3-CKT SINGLE CONDUCTOR
OF TRANSMISSION LINE

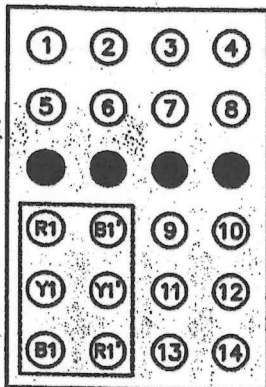


1-CKT BUNDLED CONDUCTOR
OF TRANSMISSION LINE

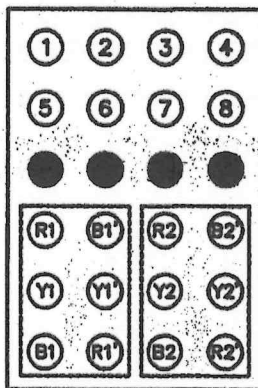

2-CKT BUNDLED CONDUCTOR
OF TRANSMISSION LINE

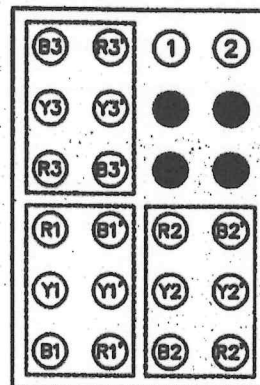


3-CKT BUNDLED CONDUCTOR
OF TRANSMISSION LINE

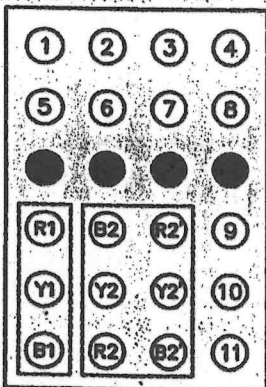

1-CKT SINGLE AND 1-CKT BUNDLED CONDUCTOR
OF TRANSMISSION LINE

● - SPARE DUCT

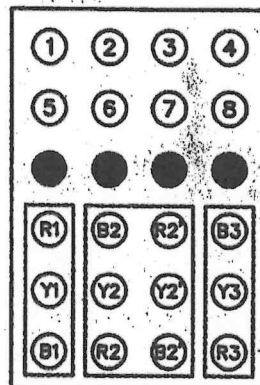


2-CKT SINGLE AND 1-CKT BUNDLED CONDUCTOR
OF TRANSMISSION LINE

NOTES

1. SYMBOL R1, Y1, B1, R2, Y2, B2, ... AND R1', Y1', B1', R2', Y2', B2', ... INDICATE PHASE AND CIRCUIT SEQUENCE OF 69/115 kV UG. CABLE.
2. NUMBER 1, 2, 3, ... INDICATE CIRCUIT SEQUENCE OF 12/20 kV UG. CABLE.
3. NUMBER OF CABLE PER DUCT ARE 1 (ONE) FOR 69/115 kV UG. CABLE AND 3 (THREE) FOR 12/20 kV UG. CABLE. (MAX. 400 mm²)

FOR CONSTRUCTION REFERENCE ONLY

REV.NO.	DESCRIPTION OF REVISIONS	BY	DATE
DR. <i>Monthol</i>	CHK. <i>Pongsan</i>	METROPOLITAN ELECTRICITY AUTHORITY	SCALE NONE
DIR.DIV. <i>R. Thana</i>		CIRCUIT ARRANGEMENT	SUPERSEDING
DIR.DEPT. <i>A. Moanwan</i>		OF	SH.NO. 2 OF 2
DEP.GOV. <i>Uga</i>		UG. CABLE IN DUCT BANK	DWG. NO. UG-4-002
DATE 9/12/2546			


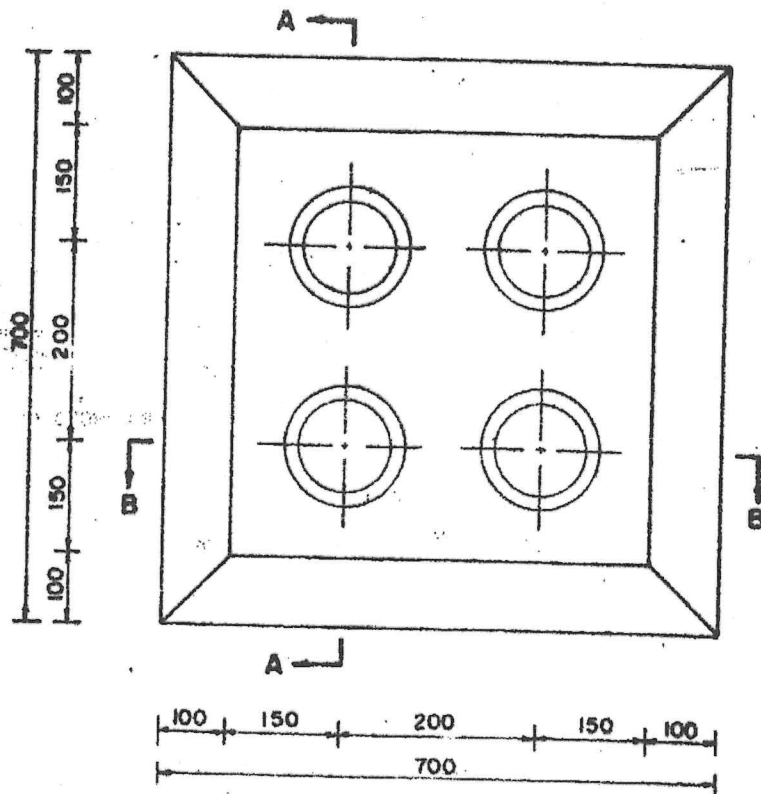


TYPICAL DUCT WINDOW END BELL
(Ø 140 MM. HDPE CONDUIT)

NOTES.

1. DIMENSIONS ARE IN MM.
2. OTHER CONFIGURATIONS OF DUCT BANKS ARE THE SAME.
3. SEE SECTION VIEW ON SH. NO. 2
4. APPLICATION: FOR UG. PRIMARY AND SUBTRANSMISSION CONSTRUCTION.


REV. NO.	DESCRIPTION OF REVISIONS		BY	DATE
DR. <i>CHK. Sombod</i>	METROPOLITAN ELECTRICITY AUTHORITY		SCALE 1:10	
DIV. CHIEF	DUCT BANK AND CONDUIT CONSTRUCTION HDPE DUCT WINDOW END BELL		SUPERSEDING	
EXC. MGR.			SH. NO. 1 OF 4	
DTY. GEN. MGR.			DWG. NO. UG-3-110	
DATE 2530				

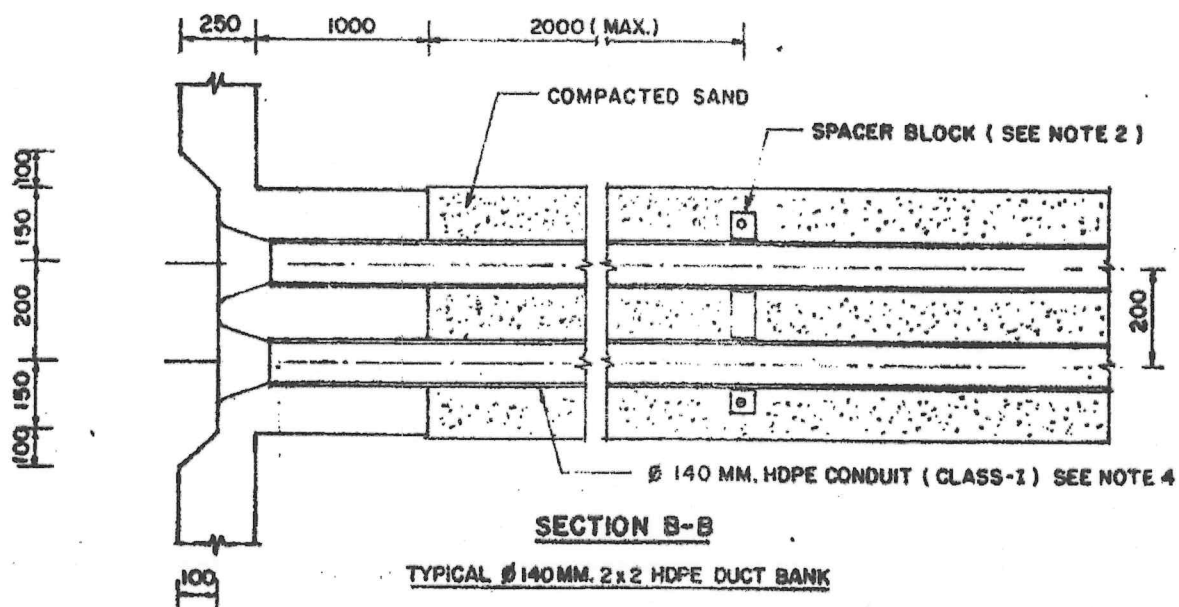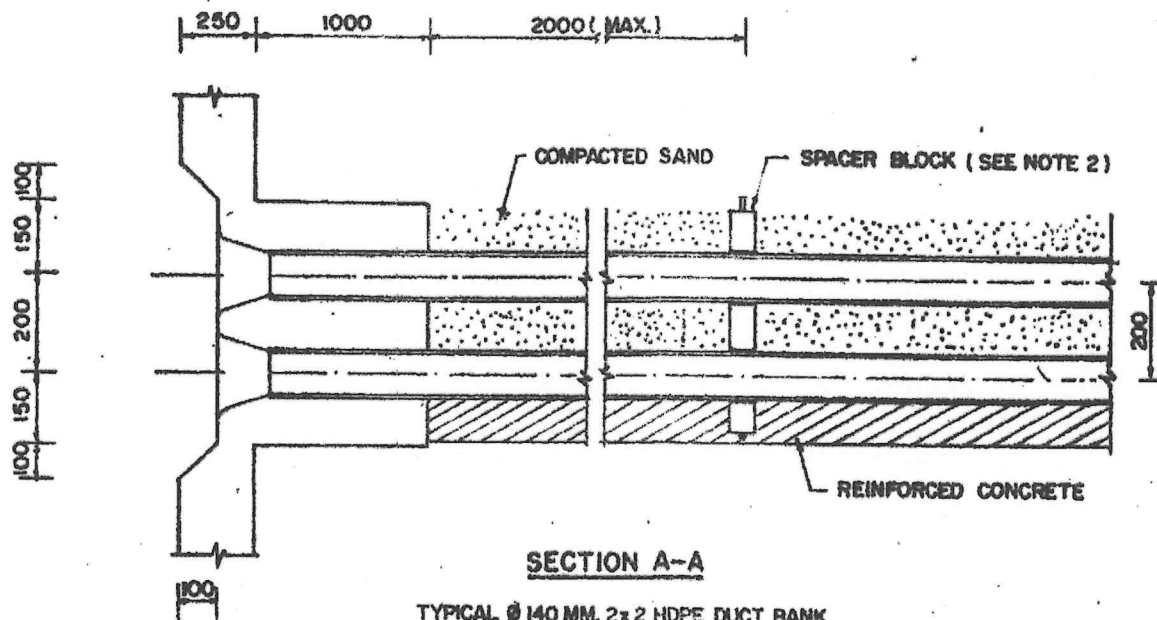

NOTES.

1. DIMENSIONS ARE IN MM.
2. FOR DETAILS OF SPACER BLOCK CONSTRUCTION, SEE DWG NO. UG-3-100
3. SEE TYPICAL METHOD OF FORMING DUCT ENTRY ON SH. NO. 3
4. FOR DETAILS OF HDPE CONDUIT, SEE DWG. NO. UG-8-008.

REV. NO.	DESCRIPTION OF REVISIONS			BY	DATE
DR. <i>[Signature]</i>	CHK. <i>[Signature]</i>	METROPOLITAN ELECTRICITY AUTHORITY			SCALE NONE
DIV. CHIEF	DUCT BANK AND CONDUIT CONSTRUCTION			SUPERSEDING	
EXC. MGR.				SH. NO. 2 OF 4	
DTY. GEN. MGR.				DWG NO. UG-3-110	
DATE	2530	TYPICAL DUCT WINDOW END BELL VERTICAL & HORIZONTAL SPACING			

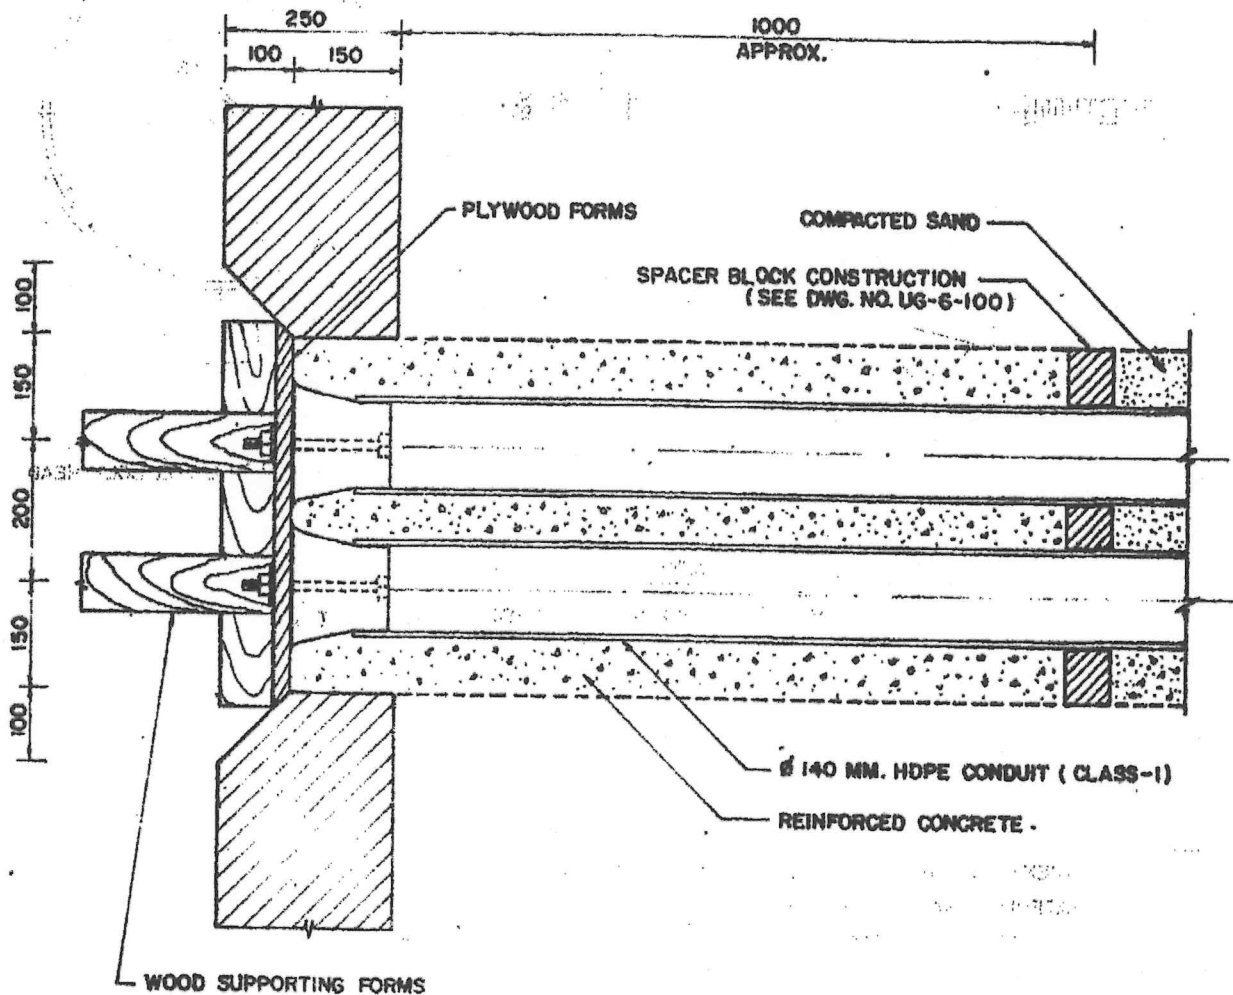


DETAIL "A"
METHOD FOR FORMING TYPICAL DUCT ENTRY
 (Ø 140 MM. 2x2 DUCT BANK)

NOTES:

1. DIMENSIONS ARE IN MM.
2. USING END BELL FORM AS SHOWN ON SH. NO. 4 TO FORM END BELL AND AFTER REMOVING END BELL FORM, THE CONCRETE SURFACE SHALL BE SMOOTHLY FINISHED.
3. FOR DETAILS OF HDPE CONDUIT, SEE DWG. NO. UG-8-008

REV. NO.	DESCRIPTION OF REVISIONS			BY	DATE
DR. <i>[Signature]</i>	CHK. <i>[Signature]</i>	METROPOLITAN ELECTRICITY AUTHORITY			SCALE NONE
DIV. CHIEF		DUCT BANK AND CONDUIT CONSTRUCTION TYPICAL METHOD FOR FORMING DUCT ENTRY			SUPERSEDING
EXC. MGR.					SH. NO. 3 OF 4
DTY. GEN. MGR.					DWG NO. UG-3-110
DATE	2530				

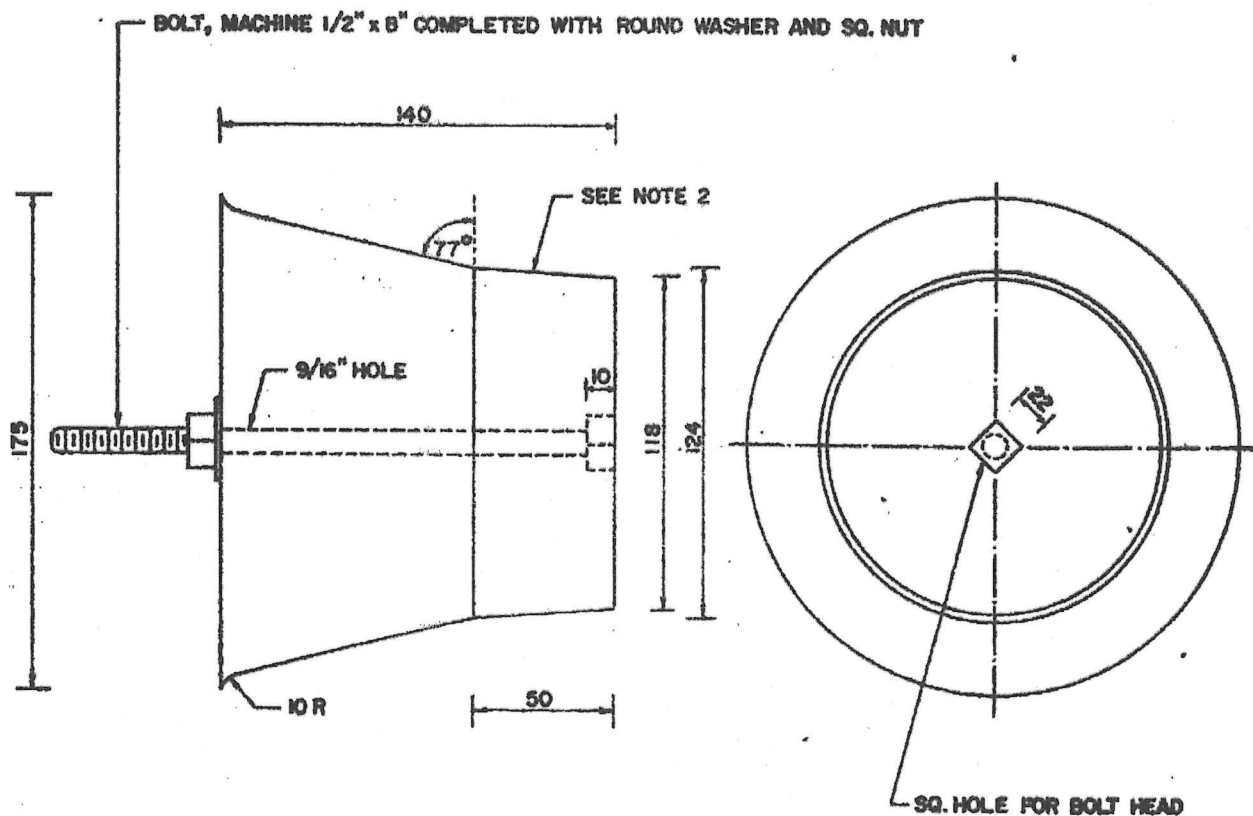


END BELL FORM
(FOR Ø 140 MM. HDPE CONDUIT CLASS-I)

NOTES.

1. DIMENSIONS ARE IN MM. UNLESS OTHERWISE SPECIFIED.
2. MATERIAL SHALL BE HARDEN WOOD.
3. SEE DETAILS OF HDPE CONDUIT CLASS-I ON DWG. NO. UG-8-008

REV. NO.	DESCRIPTION OF REVISIONS			BY	DATE
DR. <i>[Signature]</i>	CHK. <i>[Signature]</i>	METROPOLITAN ELECTRICITY AUTHORITY			SCALE 1:2.5
DIV. CHIEF	DUCT BANK AND CONDUIT CONSTRUCTION END BELL FORM FOR HDPE DUCT WINDOW			SUPERSEDING	
EXC. MGR.				SH. NO. 4 OF 4	
DTY. GEN. MGR.				DWG. NO. UG-3-110	
DATE 25.30				<i>[Signature]</i>	

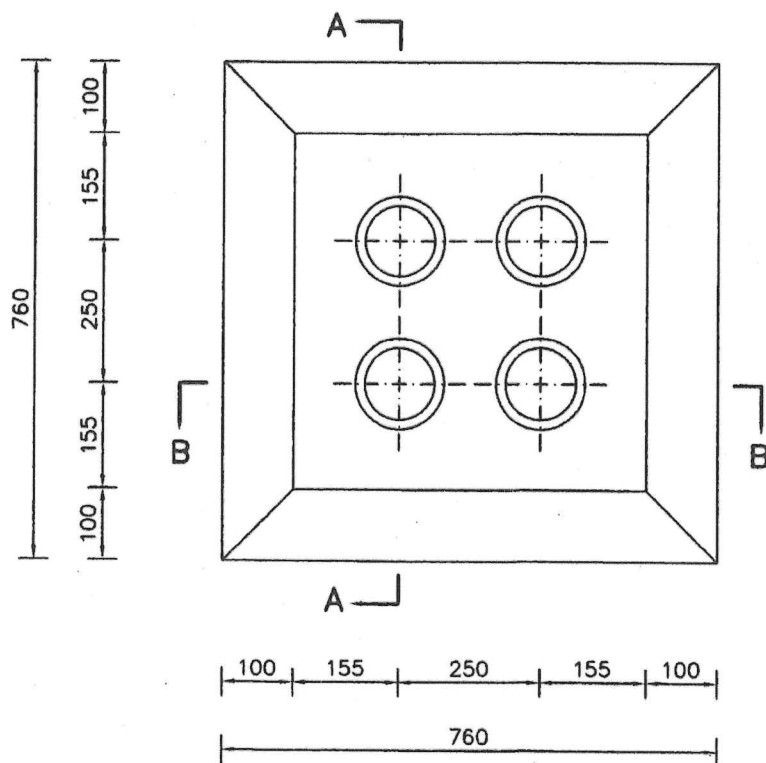

TYPICAL DUCT WINDOW END BELL
FOR $\phi 125$ mm RTRC⁴⁾



NOTES

1. DIMENSIONS ARE IN mm.
2. OTHER CONFIGURATIONS OF DUCT BANKS ARE THE SAME.
3. SEE SECTION VIEW ON SH.NO. 2
4. REFERENCE CONDUIT FOR RTRC : ท่ออีพ็อกซีเรซินเสริมใยแก้วสำหรับใช้ร้อยสายไฟฟ้า และสายโทรศัพท์ ชนิด BG ชั้นคุณภาพที่ 1 ตาม มอก. 2518-2556 หรือฉบับล่าสุด

APPLICATION : FOR UNDERGROUND PRIMARY AND SUBTRANSMISSION CONSTRUCTION.

REV.NO.	DESCRIPTION OF REVISIONS	BY	DATE
DR. <i>Gintasil</i>	ENGR. <i>Gintasil</i>		
CHF.SEC. <i>Monthol (acting)</i>			
CHK. <i>-</i>			
DIR.DIV. <i>Pongsan</i>			
DATE <i>22/5/2556</i>			

METROPOLITAN ELECTRICITY AUTHORITY	SCALE NONE
DUCT BANK AND CONDUIT CONSTRUCTION	SUPERSEDING 10A4-0401
REINFORCED THERMOSETTING RESIN CONDUIT (RTRC)	SH.NO. 1 OF 3
(CONCRETE ENCASED INSTALLATION)	DWG. NO. 10A4-0730

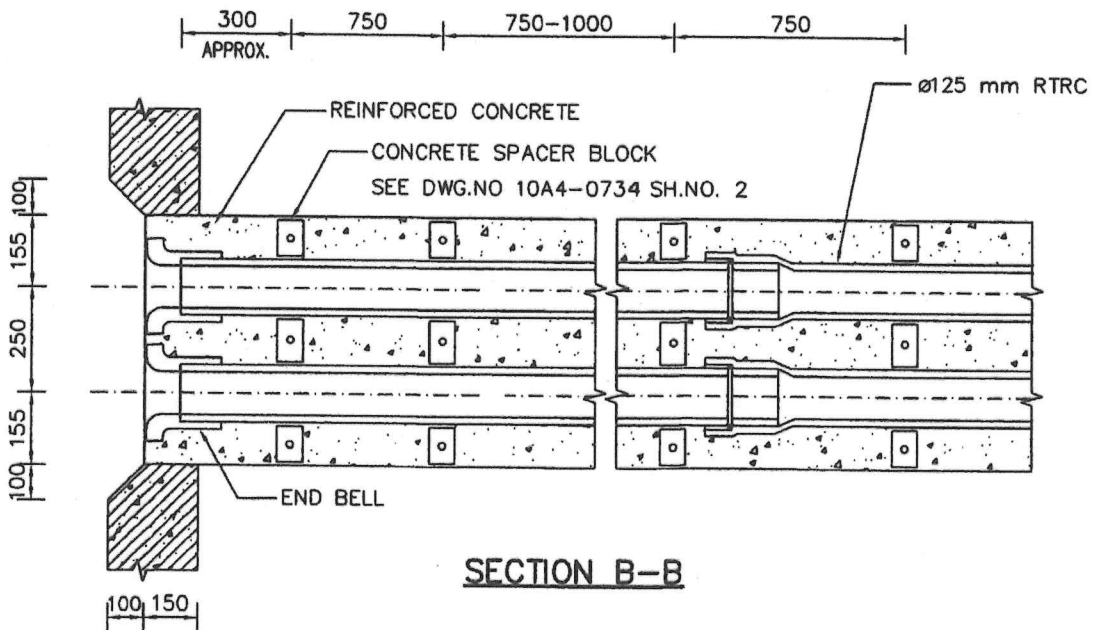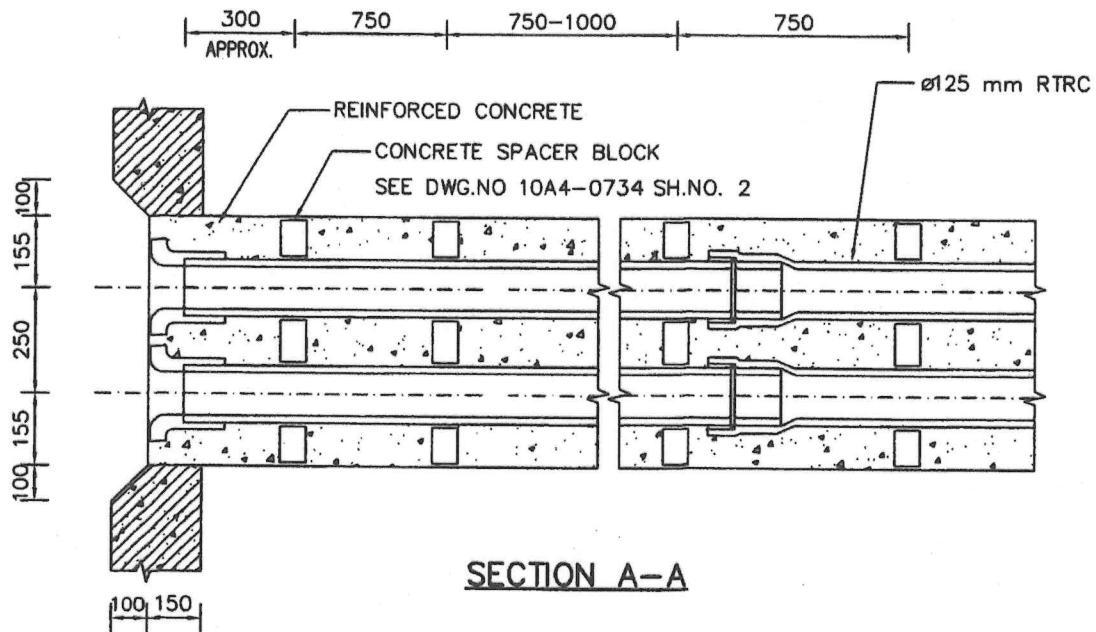

TYPICAL DUCT AND WINDOW END BELL 2 x 2 DUCT BANK

(VERTICAL AND HORIZONTAL SPACING TO BE CONCRETE ENCASED INSTALLATION)


NOTES

1. DIMENSIONS ARE IN mm.
2. SEE METHOD FOR FORMING TYPICAL DUCT ENTRY ON SH.NO. 3

APPLICATION : FOR UNDERGROUND PRIMARY AND SUBTRANSMISSION CONSTRUCTION

REV.NO.	DESCRIPTION OF REVISIONS				BY	DATE
DR. <i>Jintasil</i>	ENGR. <i>Jintasil</i>	METROPOLITAN ELECTRICITY AUTHORITY			SCALE	NONE
CHF.SEC. <i>Monthol Coating</i>	DUCT BANK AND CONDUIT CONSTRUCTION REINFORCED THERMOSETTING RESIN CONDUIT (RTRC) (CONCRETE ENCASED INSTALLATION)			SUPERSEDING 10A4-0401		
CHK. <i>-</i>				SH.NO. 2 OF 3		
DIR.DIV. <i>Pongsan</i>				DWG. NO. 10A4-0730		
DATE 22/5/2556						

[Handwritten signatures and initials]

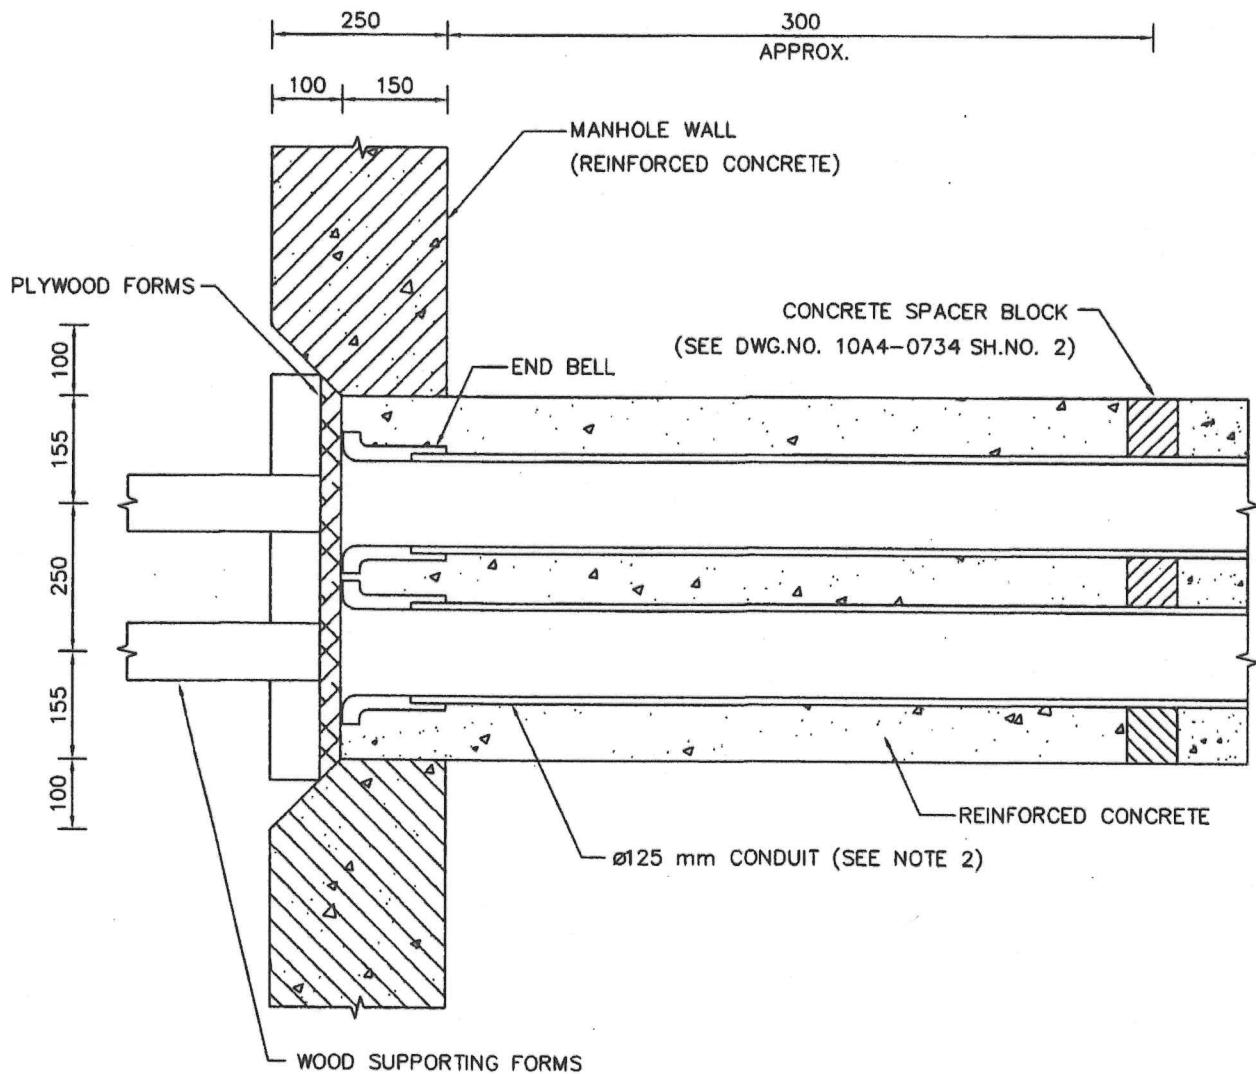

METHOD FOR FORMING TYPICAL DUCT ENTRY 2 x 2 DUCT BANK


(FOR Ø125 mm CONDUIT CLASS 1 (SEE NOTE 2))

- NOTES**
1. DIMENSIONS ARE IN mm.
 2. CONFIGURATION IS BASED ON Ø125 mm CONDUIT (SEE NOTE 3)
 3. REFERENCE CONDUIT : ท่ออีพ็อกซีเรซินเสริมใยแก้วสำหรับใช้ร้อยสายไฟฟ้า และสายโทรศัพท์ชนิด BG ชั้นคุณภาพที่ 1 ตาม มอก 2518-2556 หรือฉบับล่าสุด

APPLICATION : FOR UNDERGROUND PRIMARY AND SUBTRANSMISSION CONSTRUCTION

REV.NO.	DESCRIPTION OF REVISIONS			BY	DATE
DR. <i>Jintasil</i>	ENGR. <i>Jintasil</i>	METROPOLITAN ELECTRICITY AUTHORITY			SCALE NONE
CHF.SEC. Monthol (acting)	DUCT BANK AND CONDUIT CONSTRUCTION REINFORCED THERMOSETTING RESIN CONDUIT (RTRC) (CONCRETE ENCASED INSTALLATION)			SUPERSEDING 10A4-0401	
CHK. -				SH.NO. 3 OF 3	
DIR.DIV. Pongsan				DWG. NO. 10A4-0730	
DATE 22/5/2556					

Handwritten signatures and initials.

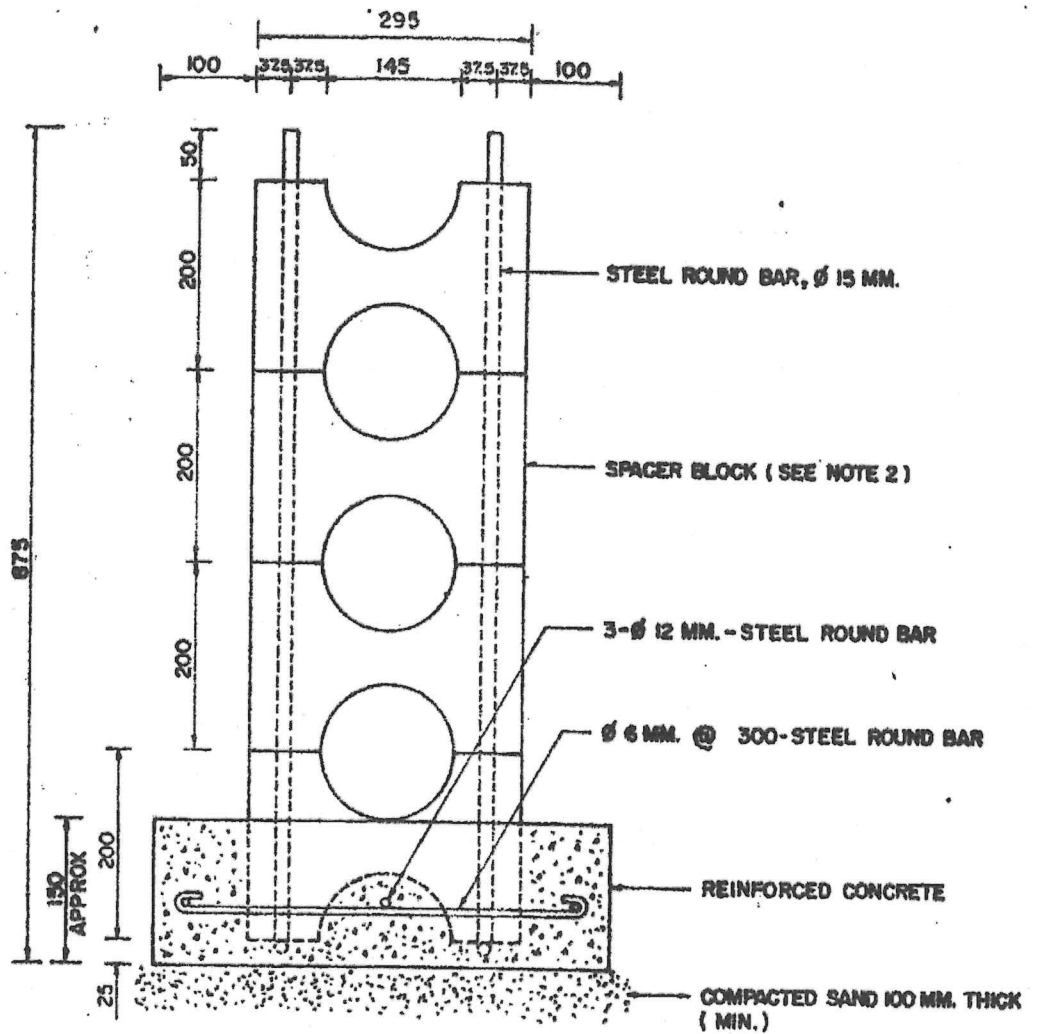


1 x 3 DUCT BANK
(Ø 140 MM. HDPE CONDUIT)

NOTES.

1. DIMENSIONS ARE IN MM. UNLESS OTHERWISE SPECIFIED.
2. SEE SPACER BLOCK DETAIL ON DWG. NO. UG-8-002 SH. NO. 2
3. APPLICATION: FOR UG. PRIMARY AND SUBTRANSMISSION CONSTRUCTION.

REV. NO.	DESCRIPTION OF REVISIONS		BY	DATE
DR. <i>M.</i>	CHK. <i>Sambal</i>	METROPOLITAN ELECTRICITY AUTHORITY	SCALE 1:75	
DIV. CHIEF	HDPE DUCT BANK		SUPERSEDING	
EXC. MGR.			SH. NO. 1 OF 4	
DTY. GEN. MGR.			DWG. NO. UG-3-100	
DATE				2530

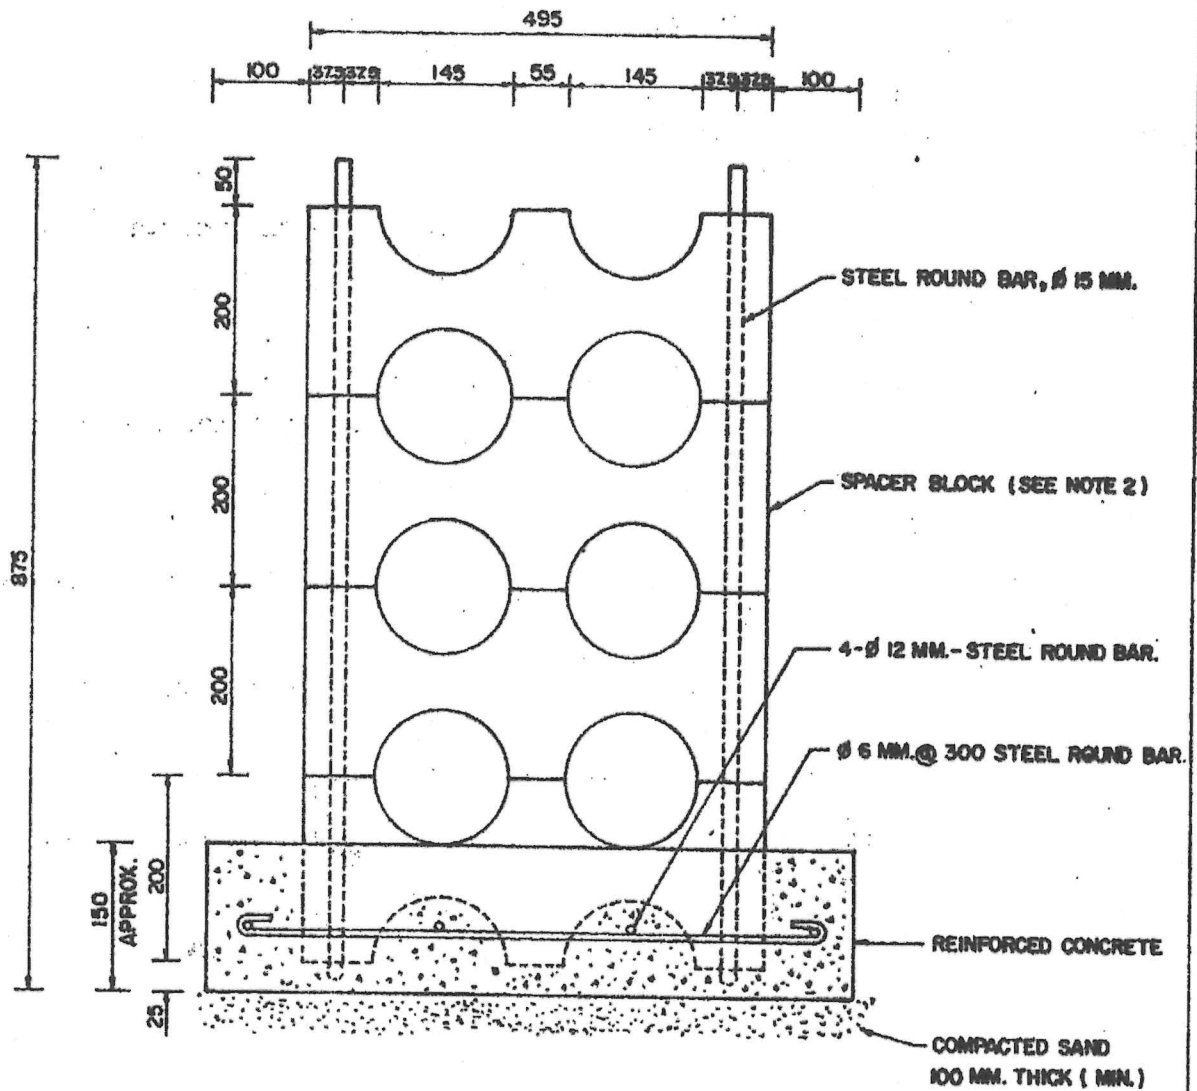


NOTES

1. DIMENSIONS ARE IN MM. UNLESS OTHERWISE SPECIFIED.
2. SEE SPACER BLOCK DETAIL ON DWG. NO. UG-8-002 SH.NO. 3
3. APPLICATION: FOR UG. PRIMARY AND SUBTRANSMISSION CONSTRUCTION.

Handwritten signature and initials


REV. NO.	DESCRIPTION OF REVISIONS	BY	DATE
DR. <i>SK</i>	CHK. <i>Sambal</i> METROPOLITAN ELECTRICITY AUTHORITY		
DIV. CHIEF		SCALE	1:7.5
EXC. MGR.		SUPERSEDING	
DTY. GEN. MGR.		SH. NO.	2 OF 4
DATE	2530	DWG. NO.	UG-3-100

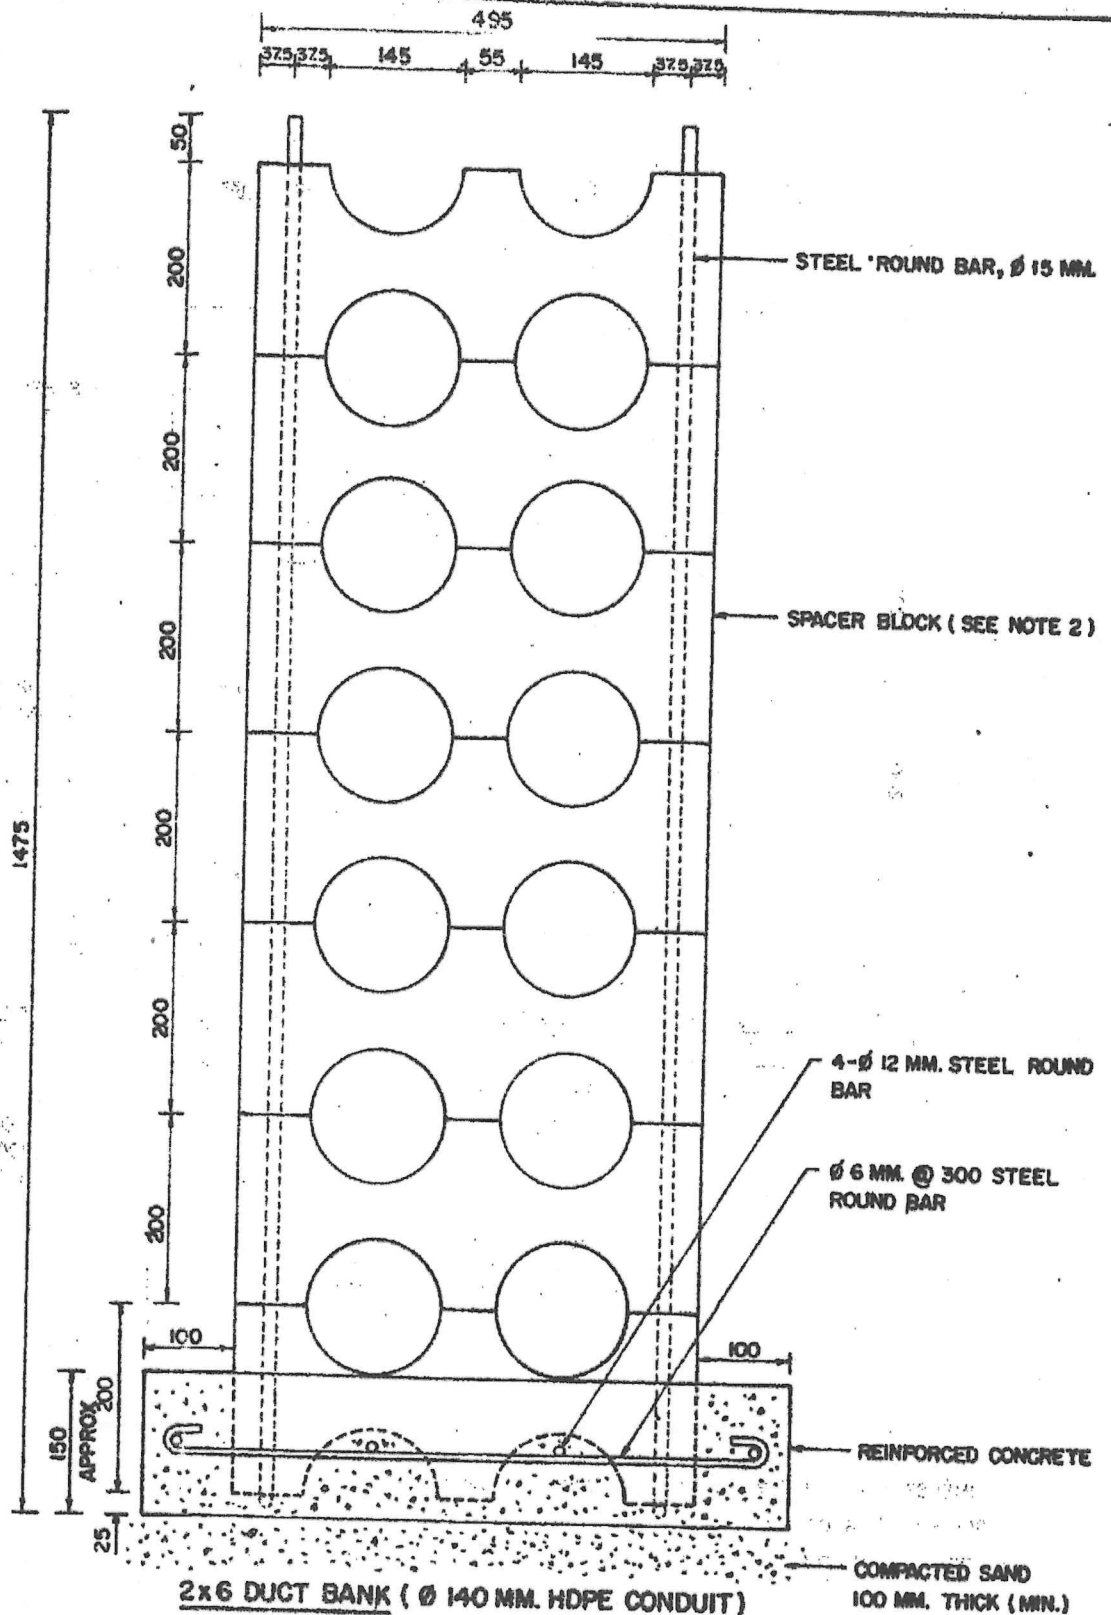

NOTES.

1. DIMENSIONS ARE IN MM. UNLESS OTHERWISE SPECIFIED.
2. SEE SPACER BLOCK DETAIL ON DWG. NO. UG-8-002 SH. NO. 3.
3. APPLICATION: FOR UG. PRIMARY AND SUBTRANSMISSION CONSTRUCTION.

REV. NO.	DESCRIPTION OF REVISIONS				BY	DATE
DR. <i>[Signature]</i>	CHK. <i>[Signature]</i>	METROPOLITAN ELECTRICITY AUTHORITY			SCALE	1:7.5
DIV. CHIEF	HDPE DUCT BANK			SUPERSEDING		
EXC. MGR.				SH. NO. 3 OF 4		
DTY. GEN. MGR.				DWG NO. UG-3-100		
DATE 2530						

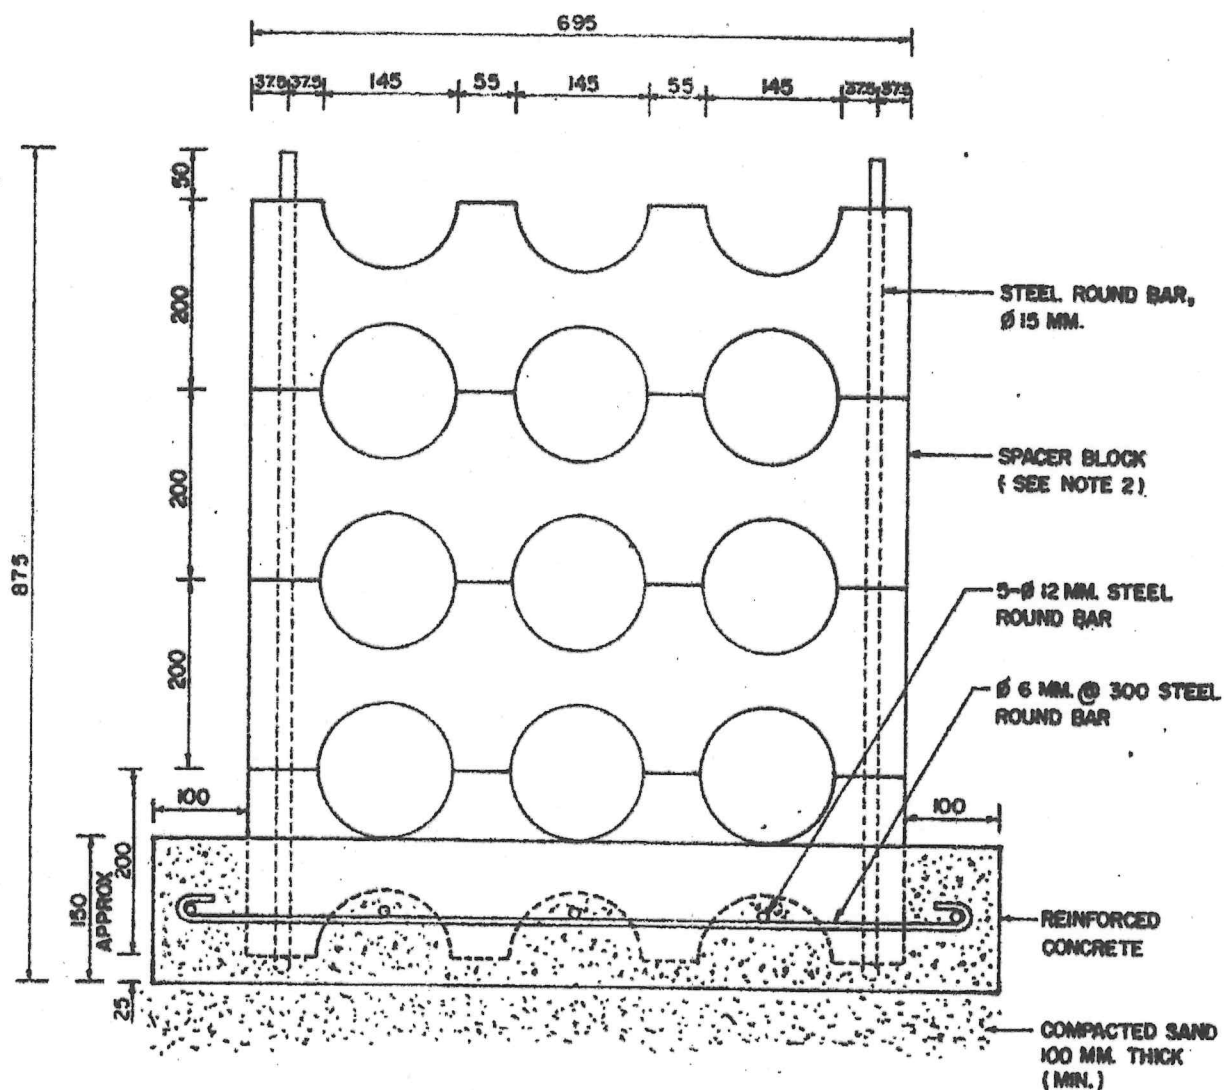


3 x 3 DUCT BANK
(Ø 140 MM. HDPE CONDUIT)

NOTES.

1. DIMENSIONS ARE IN MM. UNLESS OTHERWISE SPECIFIED.
2. SEE SPACER BLOCK DETAIL ON DWG. NO. UG-8-002 SH. NO. 3
3. APPLICATION: FOR UG. PRIMARY AND SUBTRANSMISSION CONSTRUCTION.


REV. NO.	DESCRIPTION OF REVISIONS		BY	DATE
DR. <i>Sanjay</i>	METROPOLITAN ELECTRICITY AUTHORITY		SCALE 1:25	
DIV. CHIEF	HDPE DUCT BANK		SUPERSEDING	
EXC. MGR.			SH. NO. 4 OF 4	
DTY. GEN. MGR.			DWG. NO. UG-3-100	
DATE 25/30				

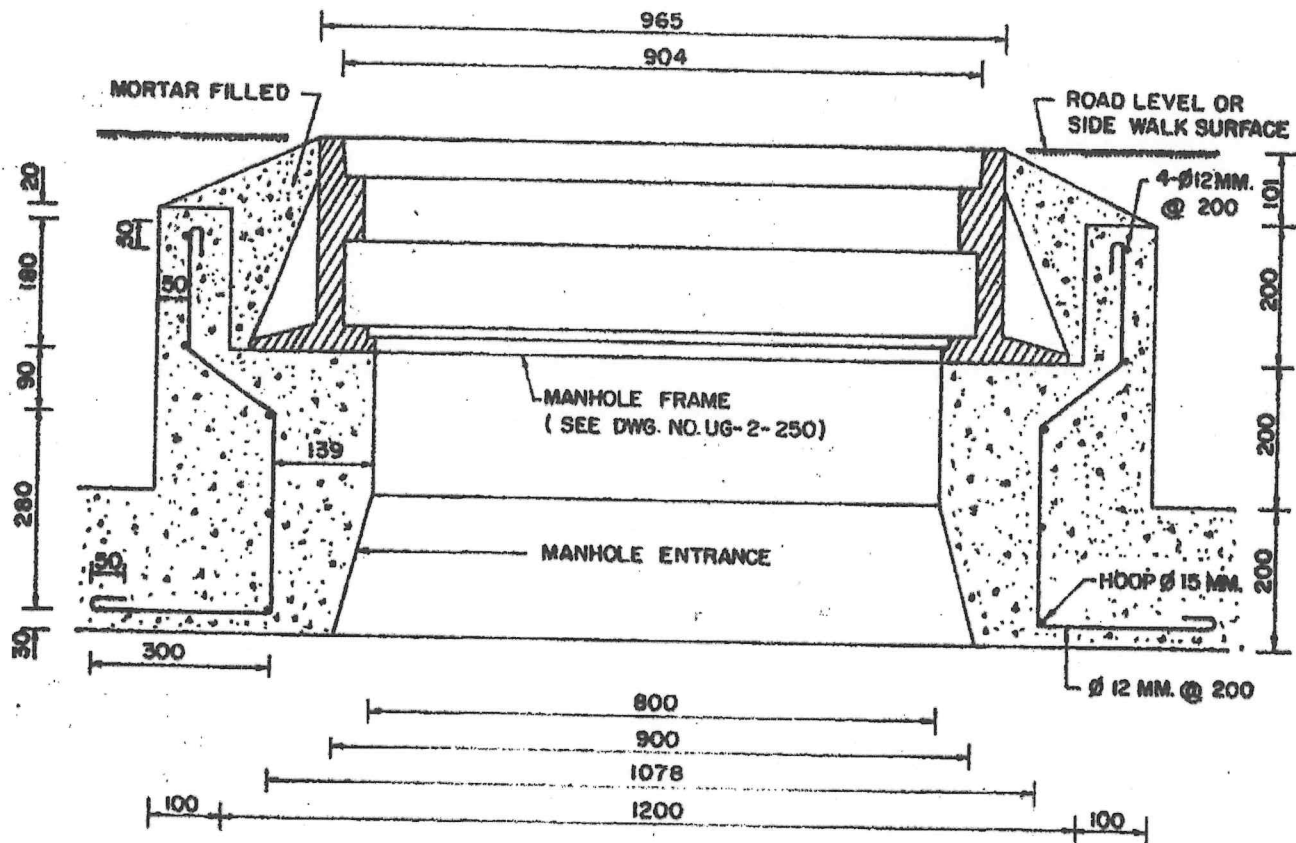

SECTION
WATER SEAL MANHOLE ENTRANCE REINFORCEMENT
 (WITH MANHOLE FRAME)

NOTE. DIMENSIONS ARE IN MM.

REV. NO.	DESCRIPTION OF REVISIONS			BY	DATE
DR. <i>[Signature]</i>	CHK. <i>[Signature]</i>	METROPOLITAN ELECTRICITY AUTHORITY			SCALE 1:10
DIV. CHIEF <i>[Signature]</i>		WATER SEAL MANHOLE ENTRANCE REINFORCEMENT			SUPERSEDING 2418
EXC. MGR. T.H.					SH. NO. 1 OF 1
DTY. GEN. MGR. <i>[Signature]</i>					DWG NO. UG-2-270
DATE 31/3/2530					

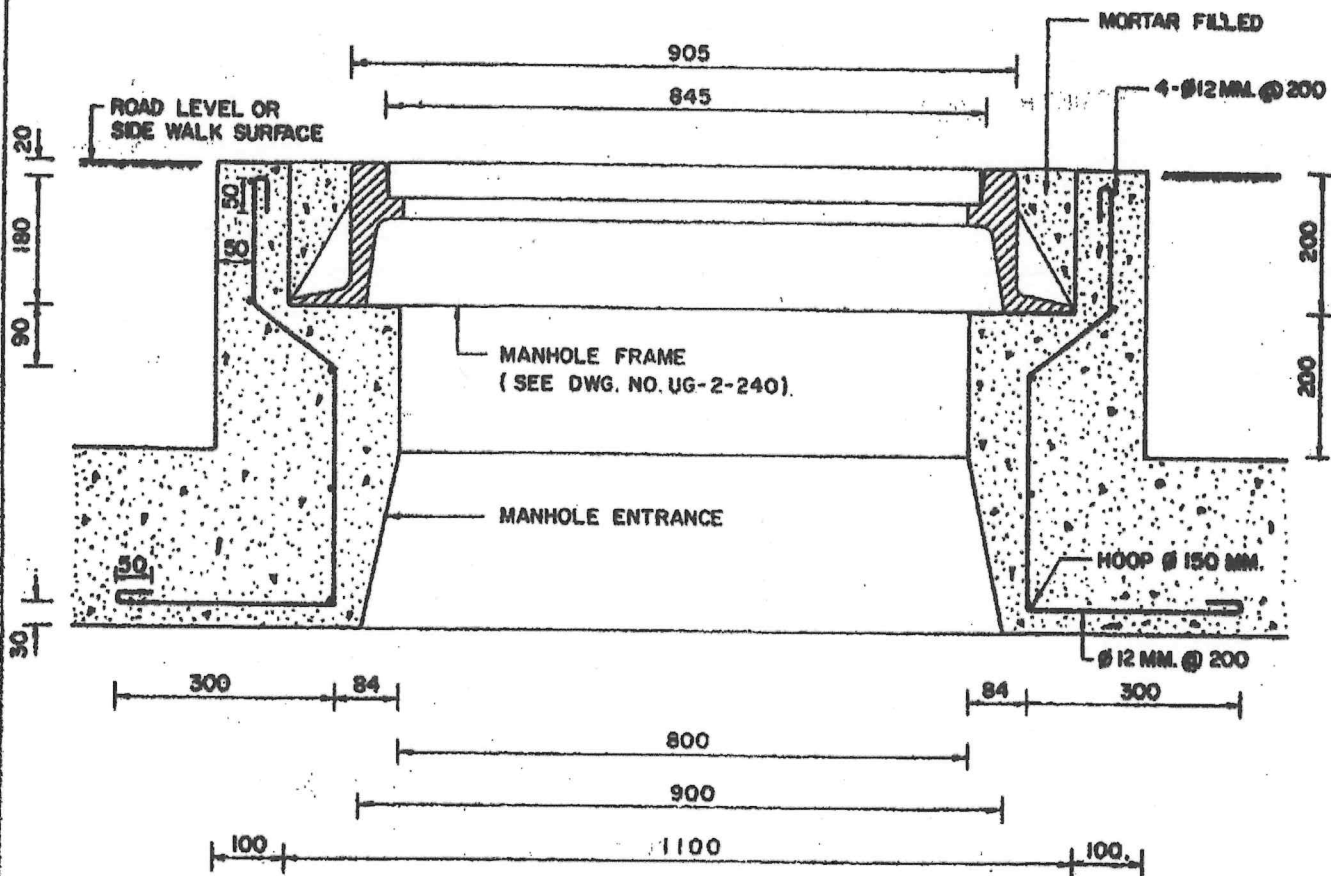


SECTION
MANHOLE ENTRANCE REINFORCEMENT (TYPE 1)
 (WITH MANHOLE FRAME)

NOTE. DIMENSIONS ARE IN MM.

Dr. Apichart

REV. NO.	DESCRIPTION OF REVISIONS	BY	DATE
DR. Apichart.	CHK Sombot.		
DIV. CHIEF	Su chart B.		
EXC. MOR.	T.H.		
DTY. GEN. MOR.	Bongkorn		
DATE	31/3/2530		
METROPOLITAN ELECTRICITY AUTHORITY		SCALE	1:10
MANHOLE ENTRANCE REINFORCEMENT		SUPERSEDING	2418
		SH. NO.	1 OF 2
		DWG. NO.	UG-2-260

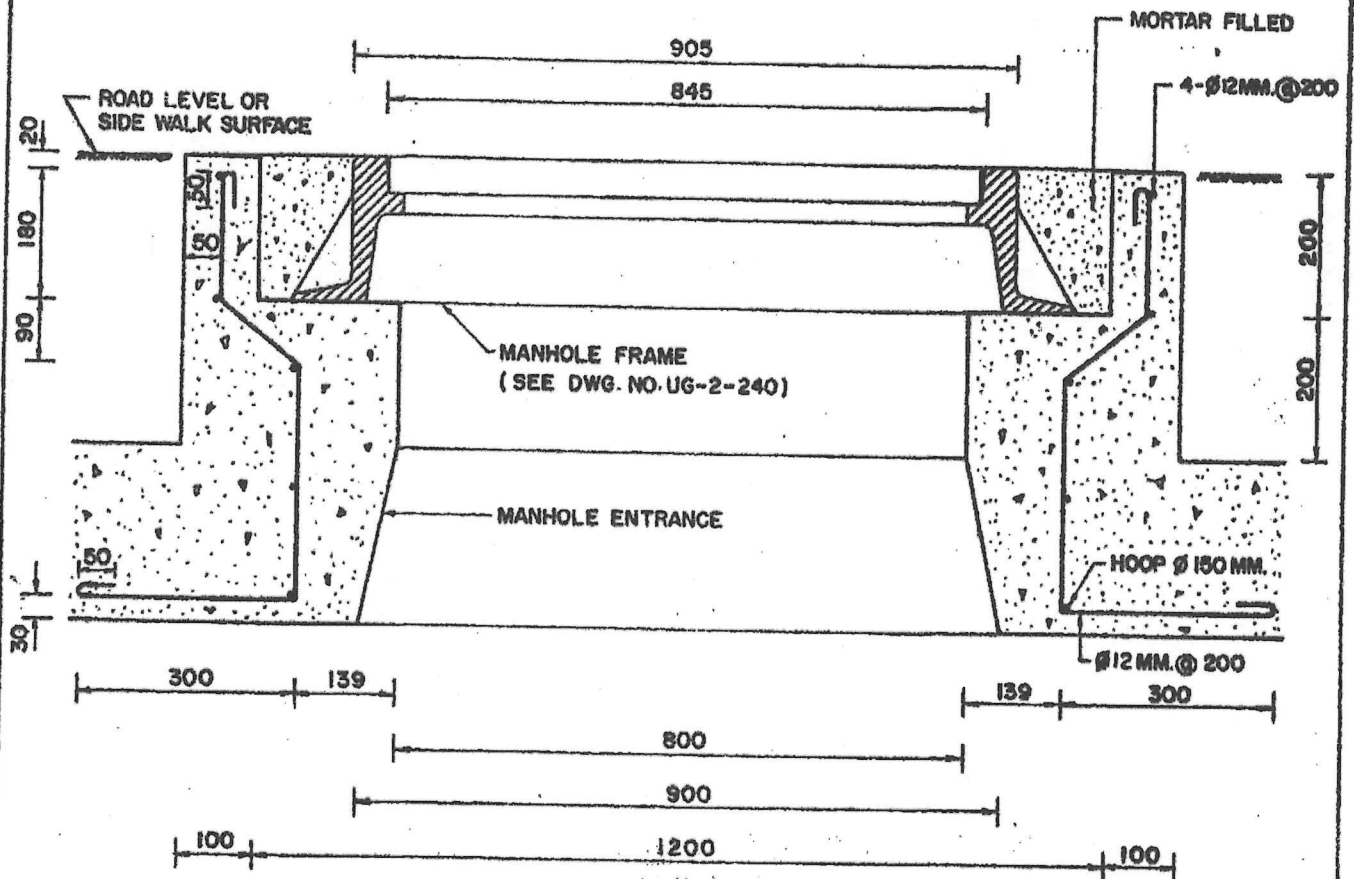


SECTION
MANHOLE ENTRANCE REINFORCEMENT (TYPE 2)
 (WITH MANHOLE FRAME)

NOTE. DIMENSIONS ARE IN MM.


Dr. [Signature]

REV. NO.		DESCRIPTION OF REVISIONS		BY	DATE
DR. <i>Apalant.</i>	CHK. <i>Sumbat.</i>	METROPOLITAN ELECTRICITY AUTHORITY		SCALE	1:10
DIV. CHIEF <i>Suchart B.</i>		MANHOLE ENTRANCE REINFORCEMENT		SUPERSEDING 2418	
EXC. MGR. <i>T.H.</i>				SH. NO. 2 OF 2	
DTY. GEN. MGR. <i>Bongu...</i>				DWG. NO. UG-2-260	
DATE 31/3/2530					

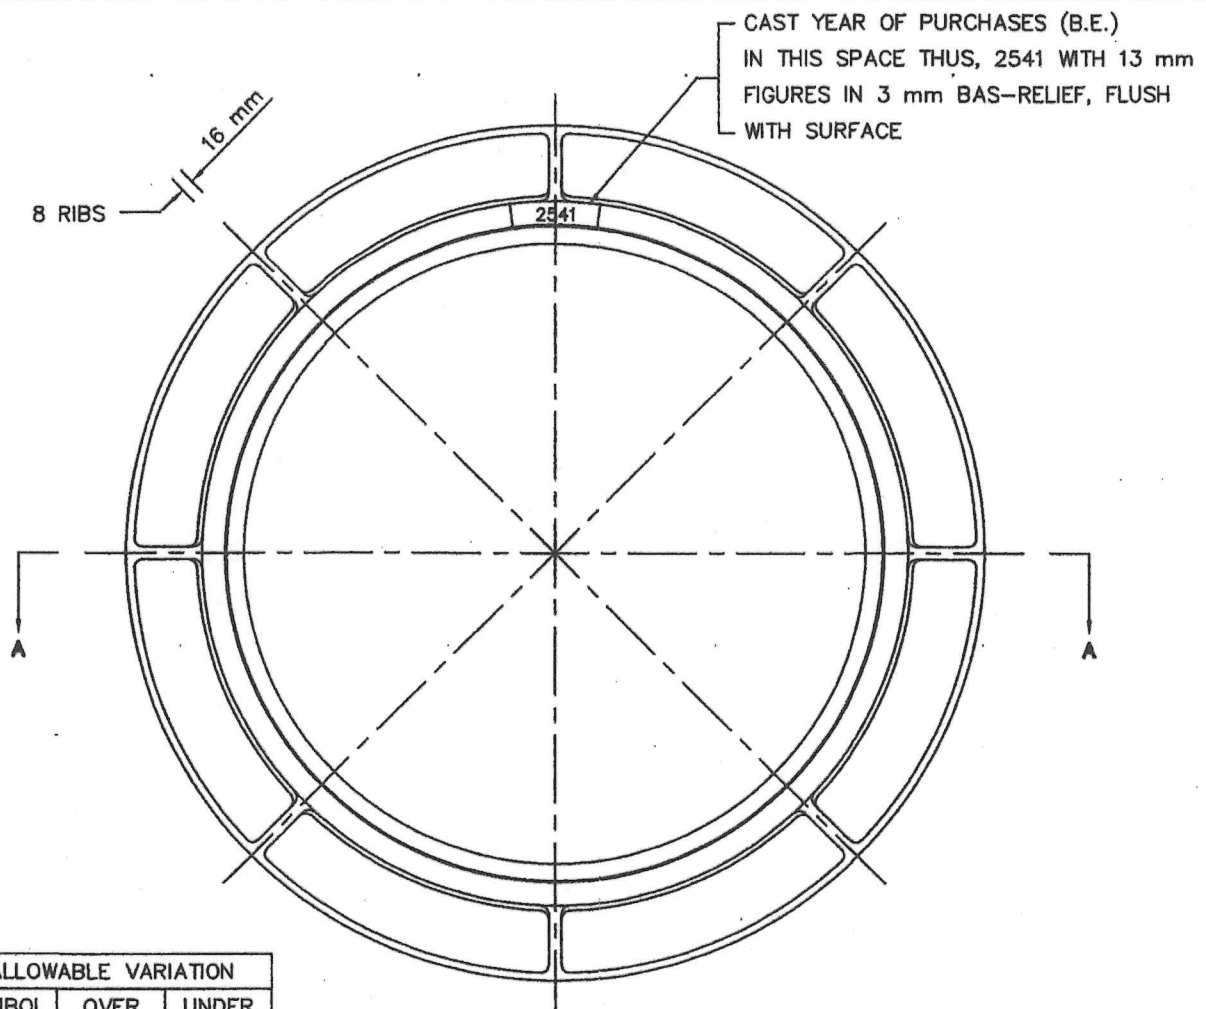

ALLOWABLE VARIATION		
SYMBOL	OVER	UNDER
C	1.5 mm	1.5 mm

MANHOLE FRAME
(CODE NO. 5620-636-31800)

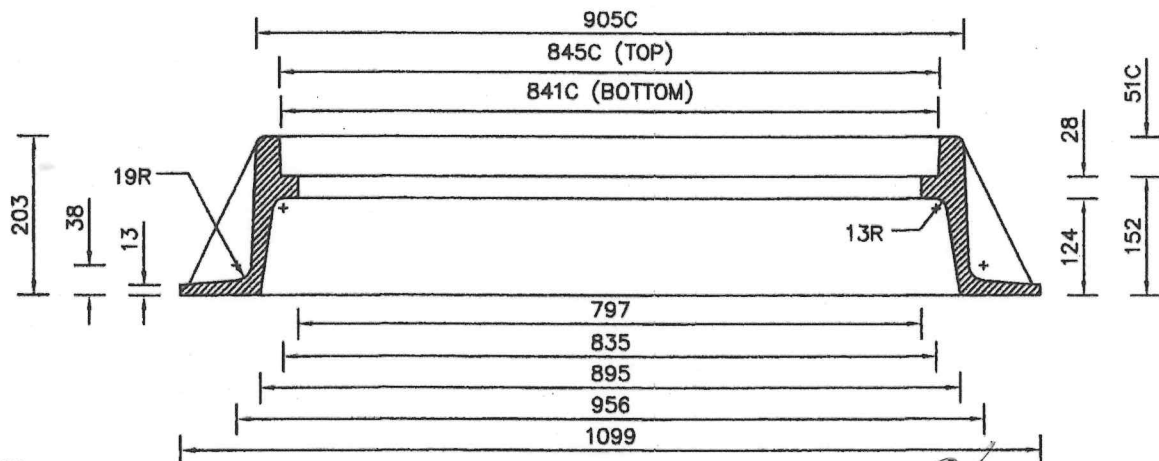


NOTES

- DIMENSIONS ARE IN mm.
- MATERIAL : SEMI-STEEL OR CAST IRON

SECTION A-A

Dr. [Signature]

2	REVISED CODE NO. OF MANHOLE FRAME	Month	10/1/61
1	CHANGED MONTH-YEAR OF MANUFACTURE TO YEAR OF PURCHASES (B.E.)	Month	26/10/61
REV. NO.	DESCRIPTION OF REVISIONS	BY	DATE
DR. [Signature]	CHK. [Signature]	METROPOLITAN ELECTRICITY AUTHORITY	
DIR. CHIEF [Signature]	MANHOLE FRAME		SCALE NONE
EXC. MGR. [Signature]	FOR		SUPERSEDING 2801
DTY. GEN. MGR. [Signature]	840 MM. DIA. MANHOLE COVER		SH. NO. 1 OF 3
DATE 31/3/2530			OWB. NO. UG-2-240

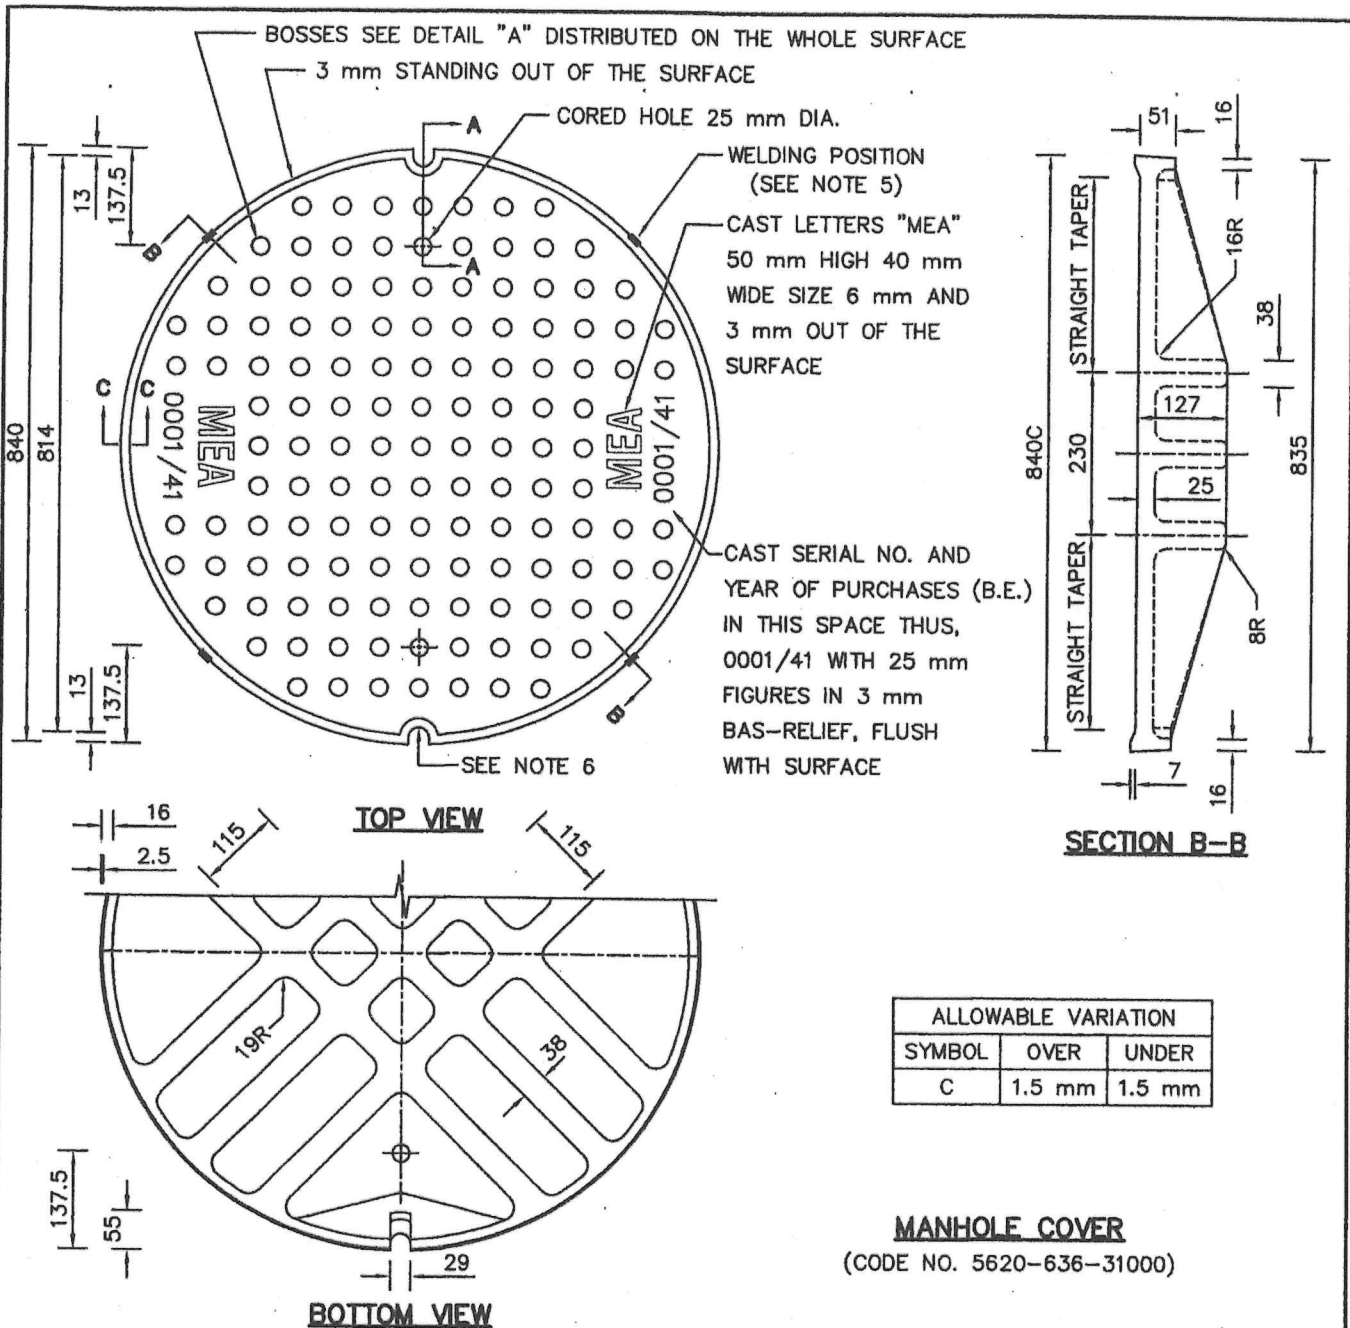

NOTES

- DIMENSIONS ARE IN mm.
- THE COVER SHALL BE EVENLY PLACED ON ITS FRAME WITHOUT MINOR ROCKING. IN CASE OF UNEVENLY SEATING OR MINOR ROCKING, SEATING SURFACE MUST BE MACHINED.
- MATERIAL : CAST IRON. REFERENCE : DWG.NO.10A1-0018
- TO BE CONTINUED ON SH.NO.3
- FRAME AND COVER SHALL BE JOINTED BY BUTT WELDING AT FOUR JOINTS, WITH UNIC100 CAST IRON RODE EACH OF 2 cm LONG AND 6 mm THICKNESS.
- TWO HOLES SHALL BE COVERED BY SHEET STEEL BUTT WELDED TO JOINT BETWEEN FRAME AND COVER WITH UNIC100 CAST IRON RODE


2	REVISED TITLE		Month	10/1/61
1	REVISED NOTE 5, ADDED NOTE 6 AND CHANGED MONTH-YEAR OF MANUFACTURE TO		By	26/10/41
	SERIAL NO.-YEAR OF PURCHASES (B.E.)			
REV.NO.	DESCRIPTION OF REVISIONS			BY DATE
DR. Peramy	CHK. Sankar.	METROPOLITAN ELECTRICITY AUTHORITY		SCALE 1:10
DIR.DIV.	Suchart A.	840 mm DIA. MANHOLE COVER		SUPERSEDING
DIR.DEPT.	T.H.			SH.NO. 2 OF 3
DEP.GOV.	Rangan			DWG. NO. UG-2-240
DATE	31/3/2530			

Dr. *[Signature]*




SECTION C-C

1	REVISED TITLE		Month	10/1/61
REV. NO.	DESCRIPTION OF REVISIONS		BY	DATE
OR REV.	CHK. <i>Susant</i>	METROPOLITAN ELECTRICITY AUTHORITY	SCALE	1:125
DR. CHIEF <i>Susant P.</i>	840 mm DIA. MANHOLE COVER		SUPERSEDES	2802
EXC. MGR. <i>T.H.</i>			SER. NO.	3 OF 3
DTY. GEN. MGR. <i>Bongard</i>			OWB. NO.	UG-2-240
DATE			31/3/2530	

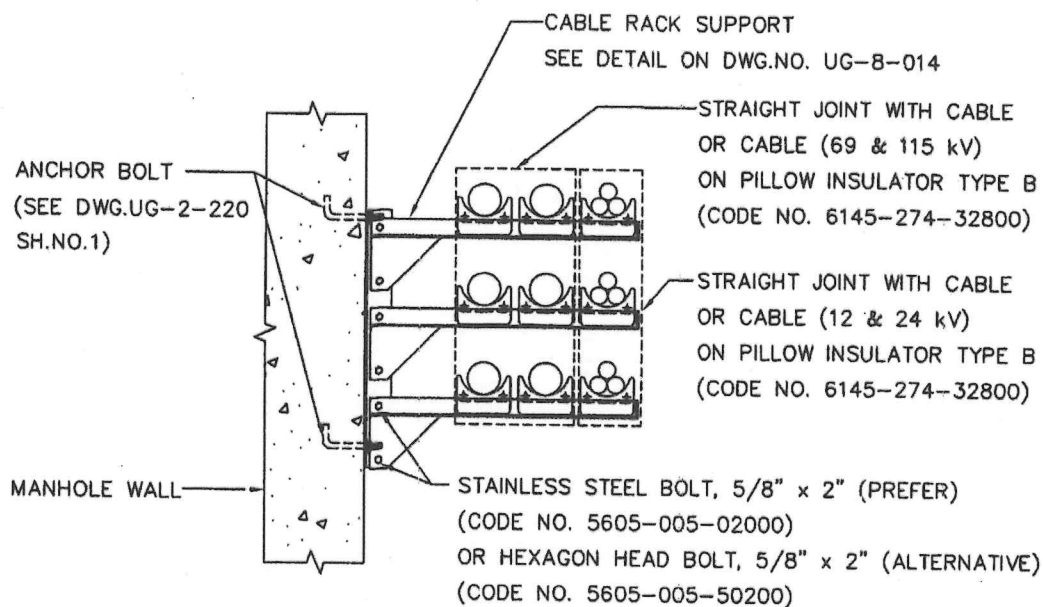

EXAMPLE 1

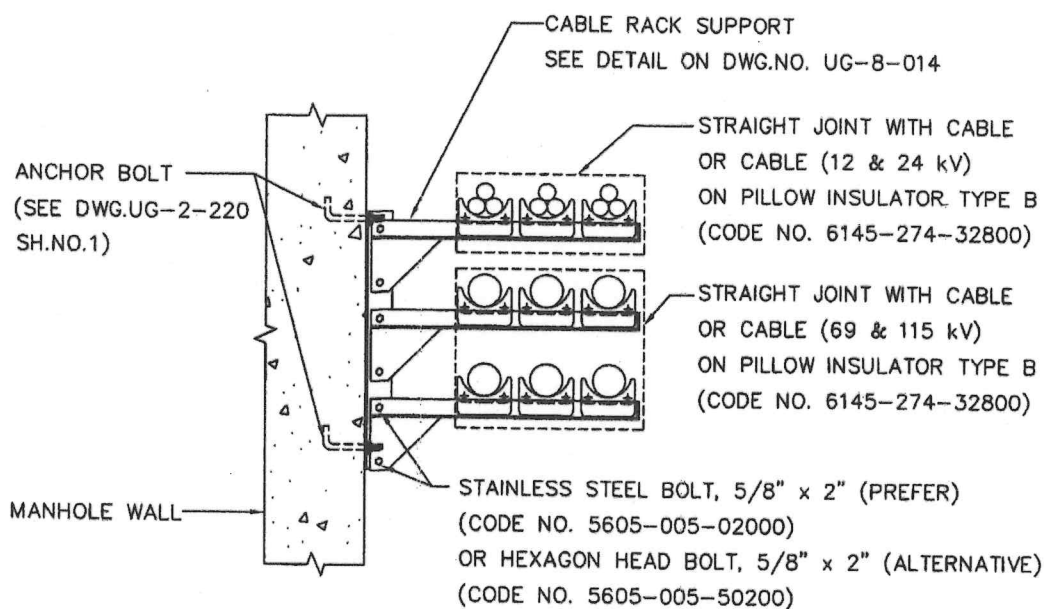

EXAMPLE 2

TYPICAL UG.CABLE INSTALLATION ON CABLE RACK SUPPORT

REV.NO.	DESCRIPTION OF REVISIONS		BY	DATE
DR. Pornchai	CHK. Pongsan	METROPOLITAN ELECTRICITY AUTHORITY TYPICAL UG.CABLE INSTALLATION ON CABLE RACK SUPPORT	SCALE	NONE
DIR.DIV. R Thir			SUPERSEDING	
DIR.DEPT. Jirachai			SH.NO. 1 OF 1	
DEP.GOV. Ugo			DWG. NO.	UG-2-221
DATE 6/6/2551				

Signature

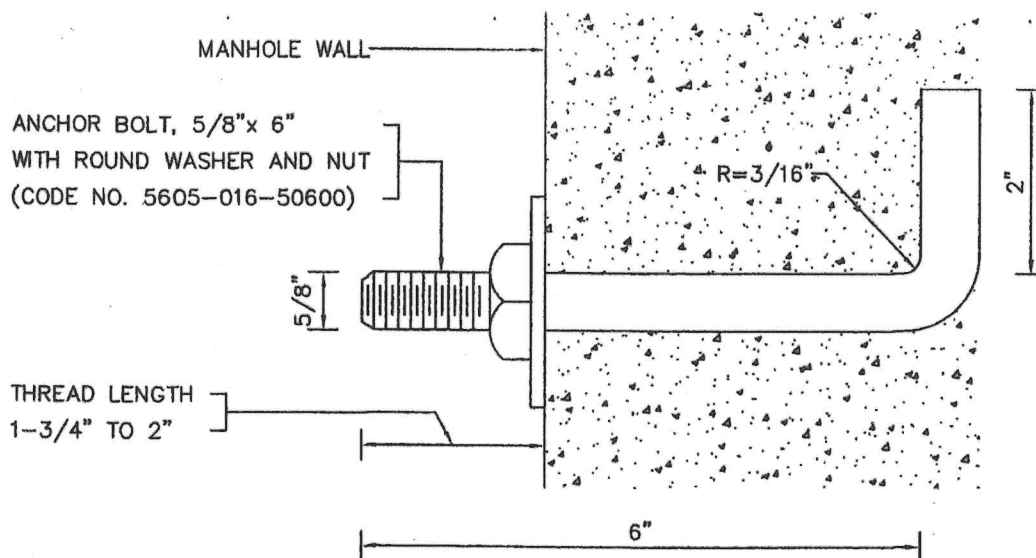


FIG.1 ANCHOR BOLT INSTALLATION (TYPICAL)


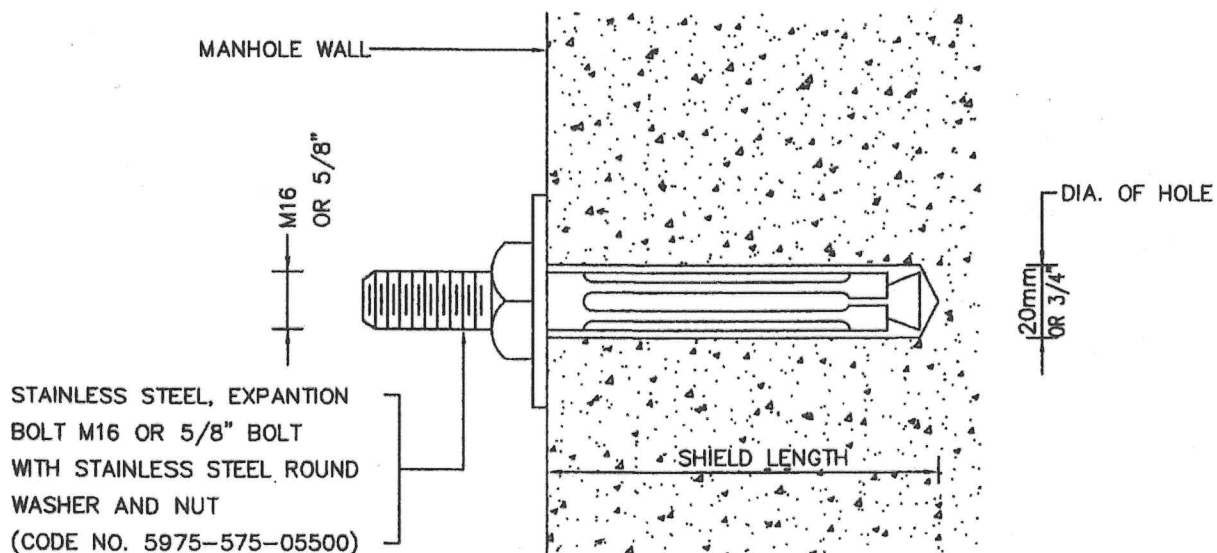


FIG.2 EXPANSION BOLT INSTALLATION (TYPICAL)

NOTE FOR MORE DETAIL, SEE MEA'S SPECIFICATION.

3	REVISED CODE NO.	Monthel	18/5/61
2	CHANGED DRILL HOLE SIZE OF EXPANSION BOLT FROM 16 mm TO 20 mm OR 3/4" 8 ADDED DRILL HOLE DEPTH.	Pongsan	29/6/47
1	CHANGE THE USE OF EXPANSION BOLT (STEEL) 3/8" TO STAINLESS STEEL EXPANSION BOLT 5/8"	Pongsan	5/9/45
REV. NO.	DESCRIPTION OF REVISIONS	BY	DATE
DP. <i>Supay</i>	CHK. <i>Pembar</i>	METROPOLITAN ELECTRICITY AUTHORITY	
DIV. CHIEF <i>Suchart B.</i>	ANCHOR BOLT AND EXPANSION BOLT		SCALE NONE
EXC. MGR. <i>T.H.</i>	FOR		SUPERSEDING 2412
DTY. GEN. MGR. <i>Pongsan</i>	UG. CABLE RACK INSTALLATION		SH. NO. 1 OF 3 <i>Oh</i>
DATE 31/3/2530			DWG. NO. UG-2-220

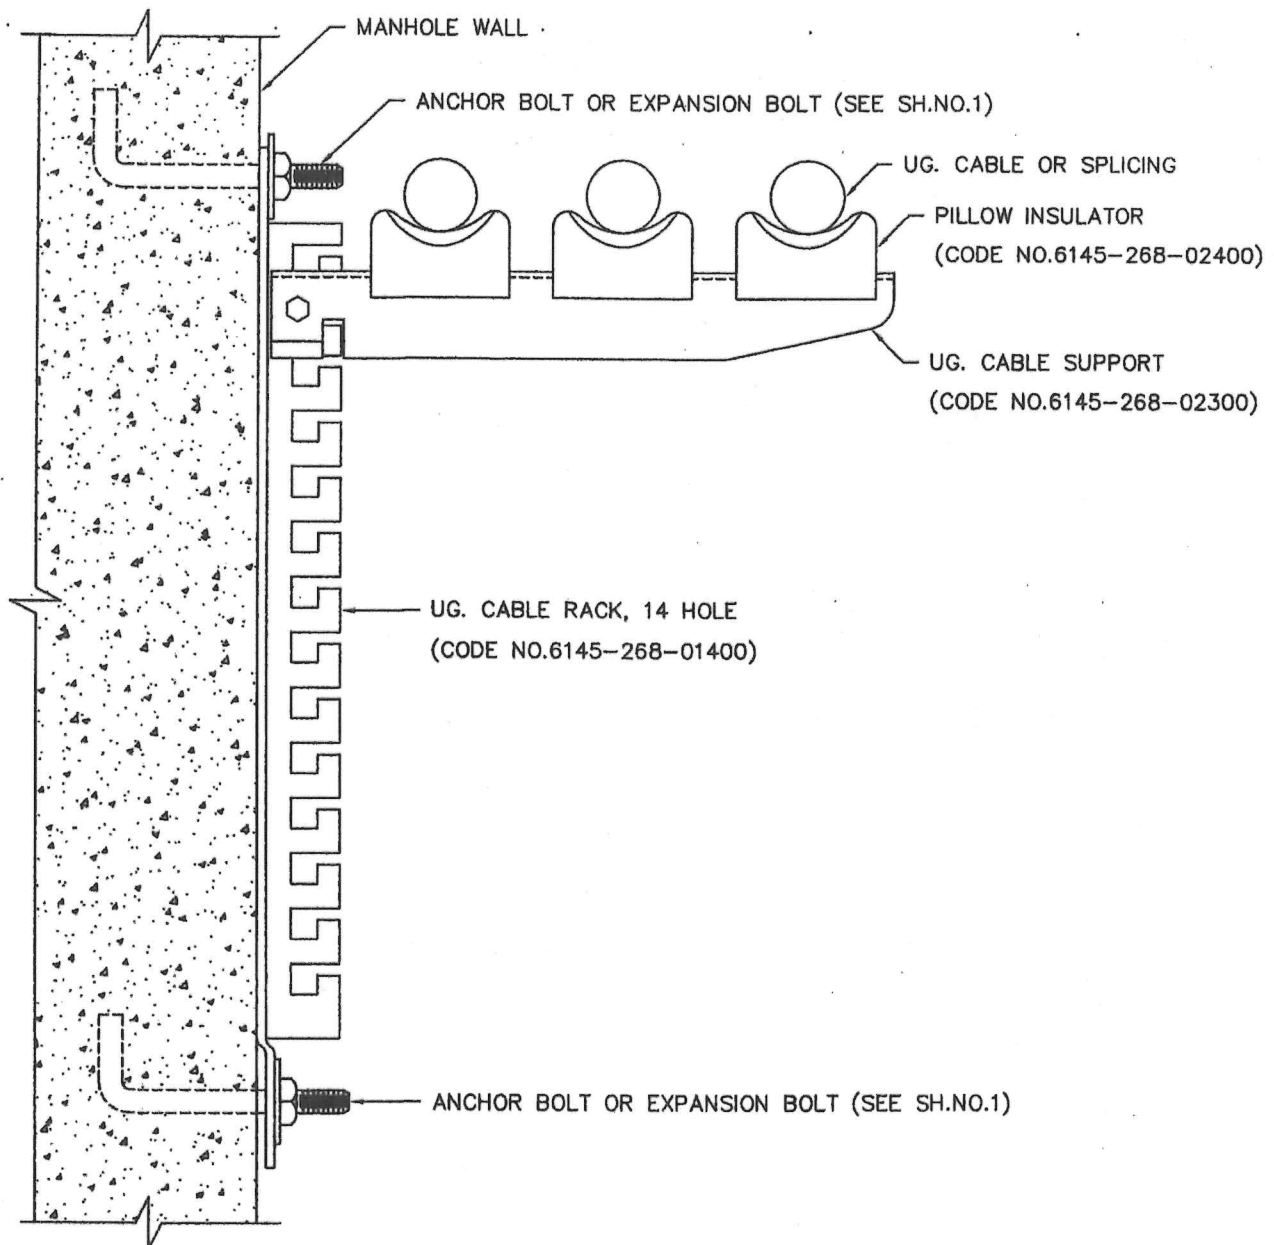

TYPICAL INSTALLATION OF UG. CABLE ON UG. CABLE RACK


NOTE SEE GROUNDING PRACTICE FOR SPLICED CABLE & CABLE RACK IN DWG.NO. UG-10-006 & UG-10-007 RESPECTIVELY.

1	REVISED CODE NO. & ADDED NOTE				Month	18/5/61
REV. NO.	DESCRIPTION OF REVISIONS				BY	DATE
OR <i>alt</i>	CHK. <i>Sambit</i>	METROPOLITAN ELECTRICITY AUTHORITY			SCALE	NONE
DIV. CHIEF <i>Suchart B.</i>	UG. CABLE RACK, SUPPORT AND PILLOW INSULATOR FOR SUPPORTING UG. CABLE & SPLICE UP TO 400 mm ²			SUPERSEDING 2412		
EXC. MGR. <i>T.H.</i>				SH. NO. 3 OF 3		
DTY. GEN. MGR. <i>Bayu 2</i>				DWG. NO. UG-2-220		
DATE 31/3/2530						


dw
Jim Kew
dw

PULLING IRON


(CODE NO. 5615-044-81200 SEE DWG. NO. UG-8-012)

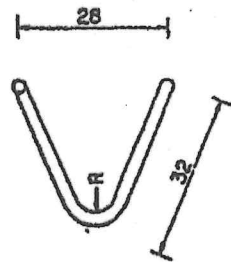

TOP VIEW
(R=30 ± 5 mm)

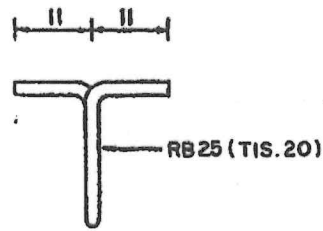

SIDE VIEW

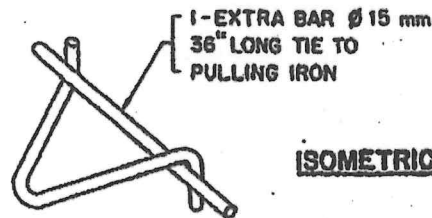

ISOMETRIC VIEW

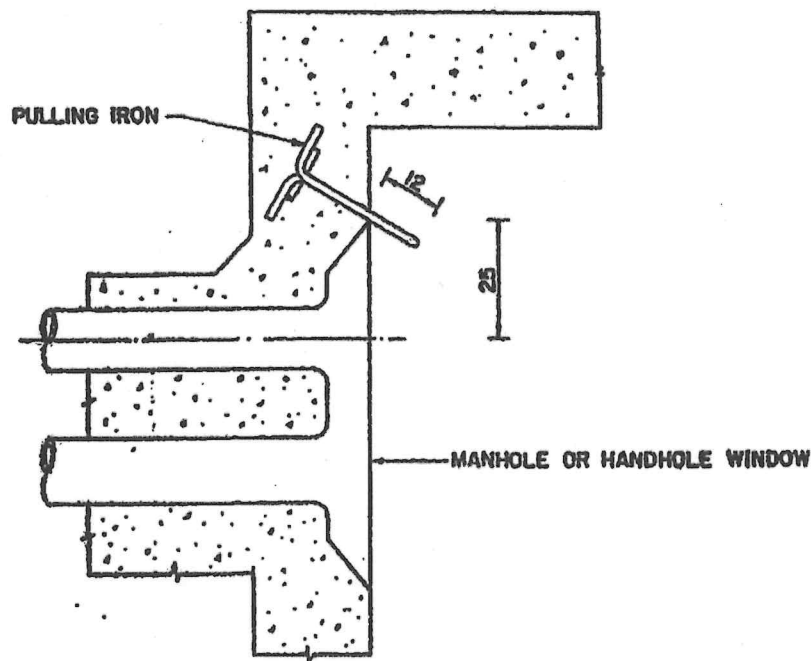


FIG.1 UPPER PULLING IRON

- NOTES.**
1. DIMENSIONS ARE IN UNLESS OTHERWISE SPECIFIED.
 2. PULLING IRON SHALL BE HOT-DIP GALVANIZED AFTER FORMING.
THE MINIMUM AVERAGE OF ZINC-COATING AS PER ASTM A123/123M.
 3. LOCATION OF PULLING IRON IN MANHOLE SHALL BE IN LINE WITH OPPOSITE DUCT BANK CENTER LINE.

1	CHANGED SIZE OF STEEL ROUND BAR FROM Ø 22 mm TO Ø 25 mm (RB 25) AND REVISED NOTE 2	VH	18/5/54
REV. NO.	DESCRIPTION OF REVISIONS	BY	DATE
OR	CHK. <i>Sundar</i>	METROPOLITAN ELECTRICITY AUTHORITY	
DIV. CHIEF	<i>Sundar B.</i>	PULLING IRON INSTALLATIONS	
EXC. MGR.	T.H.	FOR	
DTY. GEN. MGR.	<i>Sundar</i>	MANHOLE AND HANDHOLE	
DATE	31/3/2530	SCALE	NONE
		SUPERSEDING	2407
		SH. NO.	1 OF 3
		DWG. NO.	UG-2-210

Sundar

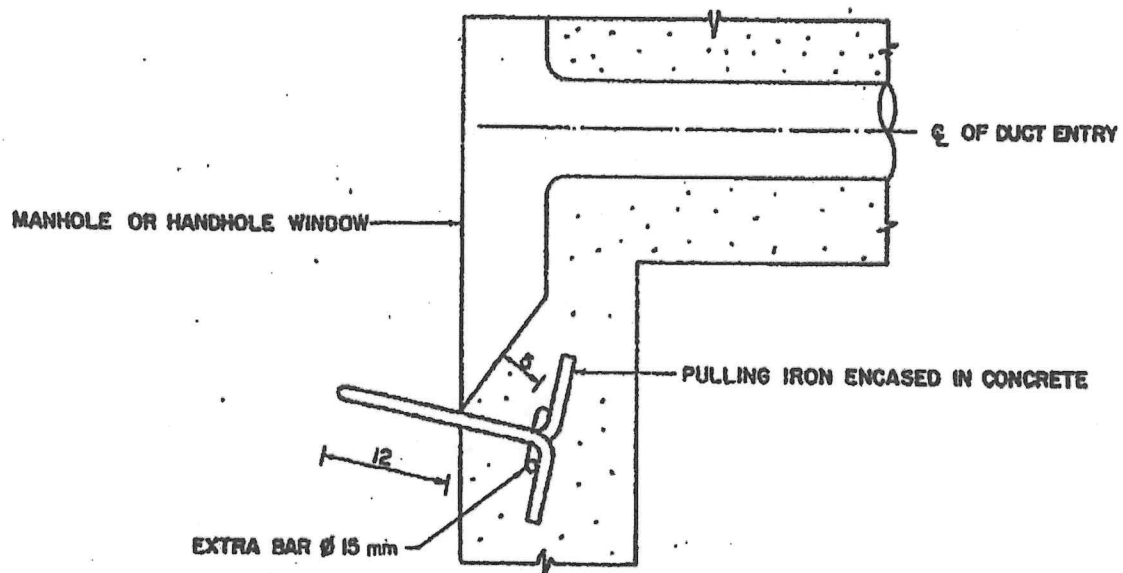


FIG. 2 LOWER PULLING IRON (TYPE 1)


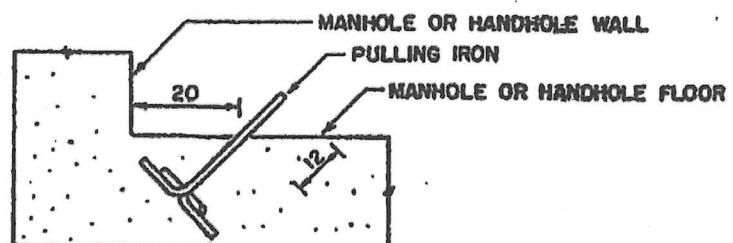


FIG. 3 LOWER PULLING IRON (TYPE 2)

NOTE. DIMENSIONS ARE IN cm


--1	CHANGED POSITION OF PULLING IRON				Sombar	7/9/32
REV. NO.	DESCRIPTION OF REVISIONS				BY	DATE
DR. <i>[Signature]</i>	CHK. <i>Sombar</i>	METROPOLITAN ELECTRICITY AUTHORITY			SCALE	NONE
DN. CHIEF <i>Sudant B.</i>	PULLING IRON INSTALLATIONS FOR MANHOLE AND HANDHOLE			SUPERSEDING 2407		
EXC. MGR. <i>T.H.</i>				SH. NO. 2 OF 3		
DTY. GEN. MGR. <i>[Signature]</i>				DWG. NO. UG-2-210		
DATE: 31/3/2030						

[Handwritten signatures and initials]

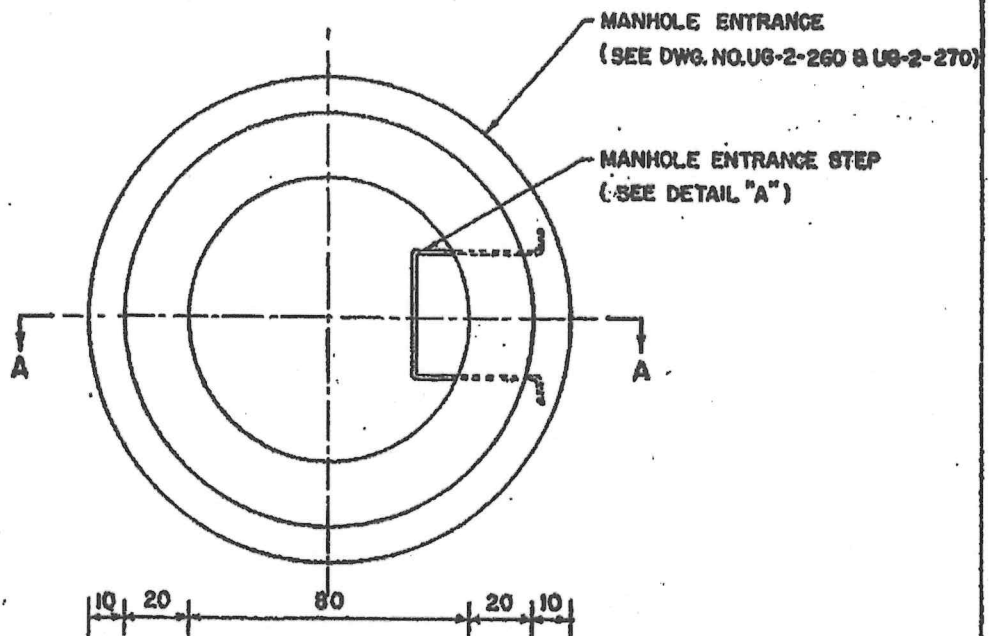


PLAN

MANHOLE ENTRANCE WITHOUT COVER

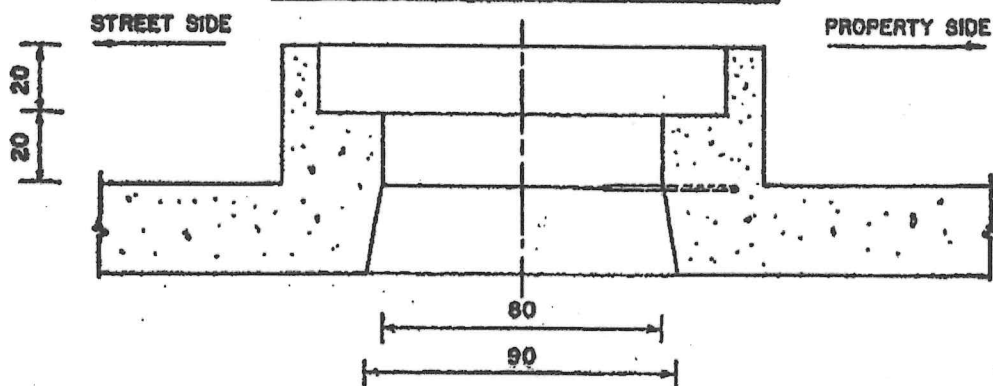

SECTION A-A

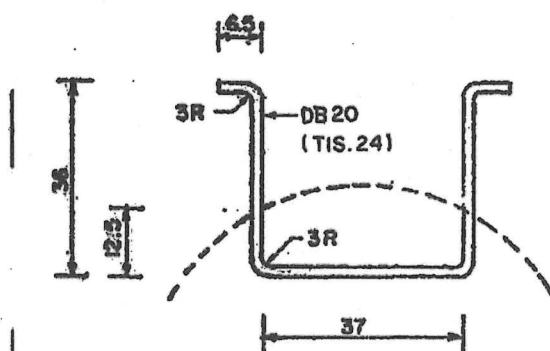

DETAIL "A"

MANHOLE ENTRANCE STEP
(CODE NO. 5620-636-00100)


NOTES.

1. DIMENSIONS ARE IN cm
2. MANHOLE ENTRANCE SHALL HAVE AT LEAST ONE MANHOLE ENTRANCE STEP AS SHOWN IN DRAWING.
3. IN CASE OF RESURFACING OF STREET SURFACE, THE HIGHER RECONSTRUCTED MANHOLE ENTRANCE SHALL HAVE MANHOLE ENTRANCE STEP EVERY 40 cm INTERVAL.
4. MANHOLE ENTRANCE STEP SHALL BE HOT-DIP GALVANIZED AFTER FORMING. THE MINIMUM AVERAGE OF ZINC-COATING AS PER ASTM 123/123M.


1	CHANGED SIZE & TYPE OF MANHOLE ENTRANCE STEP TO DB 20 AND REVISED NOTE 4			VH	18/5/59
REV. NO.	DESCRIPTION OF REVISIONS			BY	DATE
DR. <i>Saty.</i>	CHK. <i>Bombal</i>	METROPOLITAN ELECTRICITY AUTHORITY		SCALE NONE	
DIV. CHIEF <i>Sachdev B.</i>	MANHOLE ENTRANCE STEP		SUPERSEDING		
EXC. MGR. T.H.			SH. NO. 3 OF 3		
DTY. GEN. MGR. <i>Bing mid</i>			DWG. NO. UG-2-210		
DATE 31/3/2530					

Cham Reservo

PULLING IRON (SEE NOTE 3.2)
SHALL BE IN LINE WITH
OPPOSITE DUCT BANK
CENTER LINE

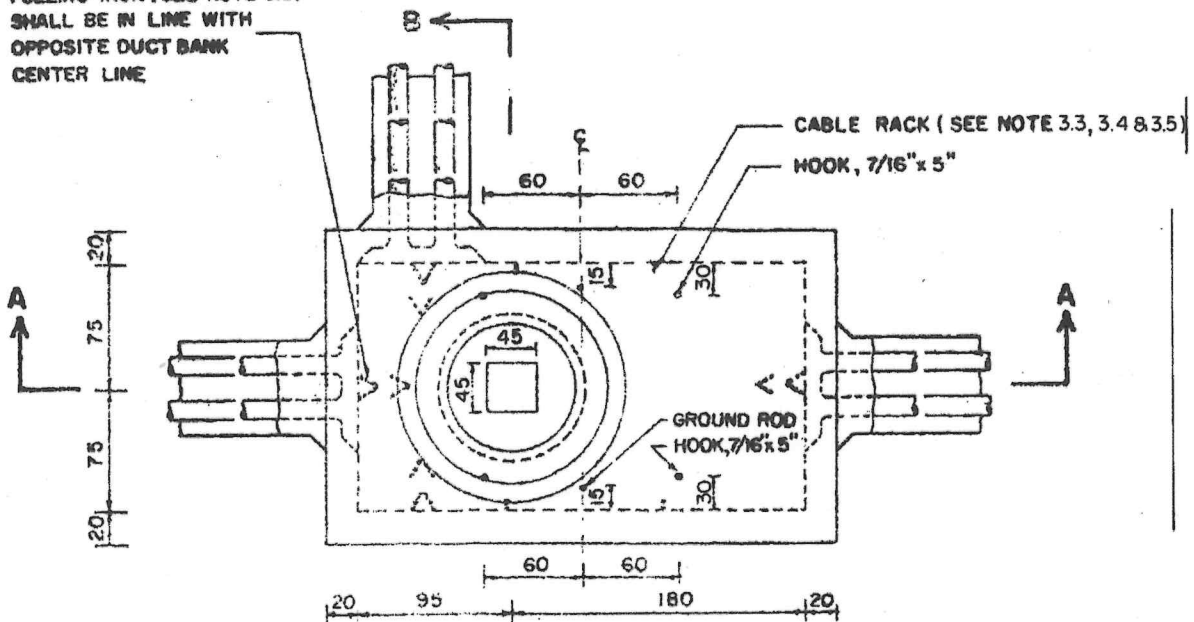


PLAN

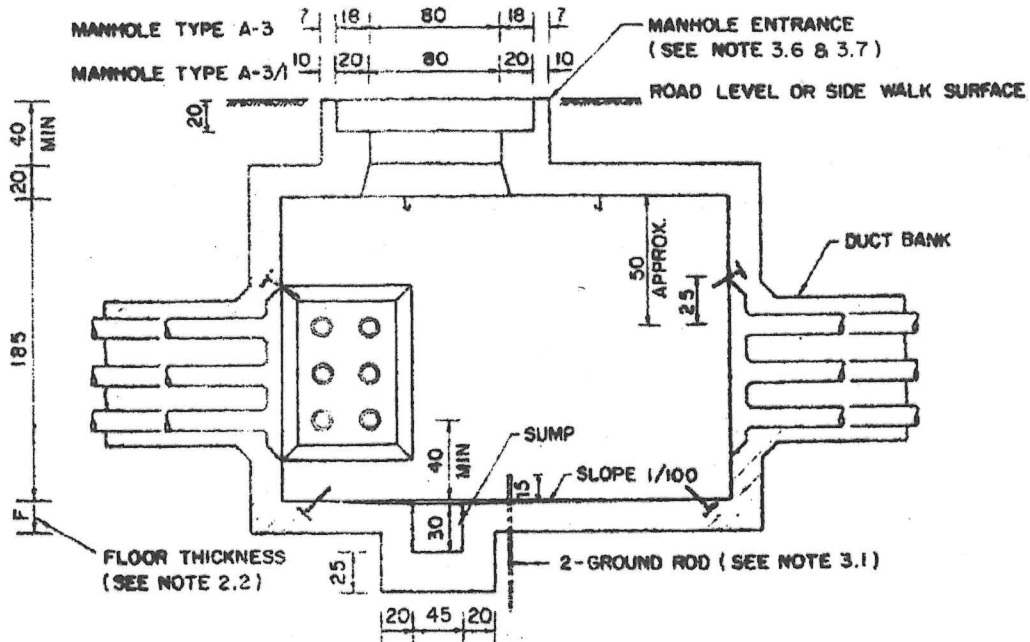

SECTION A-A

2	CHANGED SIZE OF SUMP & POSITION OF HOOK AND REVISED WORDING	Handed	5/11/55
1	CHANGED POSITION OF PULLING IRON AND DRIVE HOOK	Sambel	7/9/32
REV. NO.	DESCRIPTION OF REVISIONS	BY	DATE
DR. Apichat	CHK. Sambel	METROPOLITAN ELECTRICITY AUTHORITY	
ON. CHIEF S.uchart B.	MANHOLE TYPE A-3 AND A-3/I		SCALE NONE
ENG. MGR. T.H.	FOR		SUPERSEDING 2405
STY. GEN. MGR. Samjunt	12/24 KV. UNDERGROUND CONSTRUCTION		SIN. NO. 1 OF 3
DATE 3/13/2530			DWG NO. UG-2-012

Handwritten signatures and initials:
 al
 Kromthasaw
 Sh

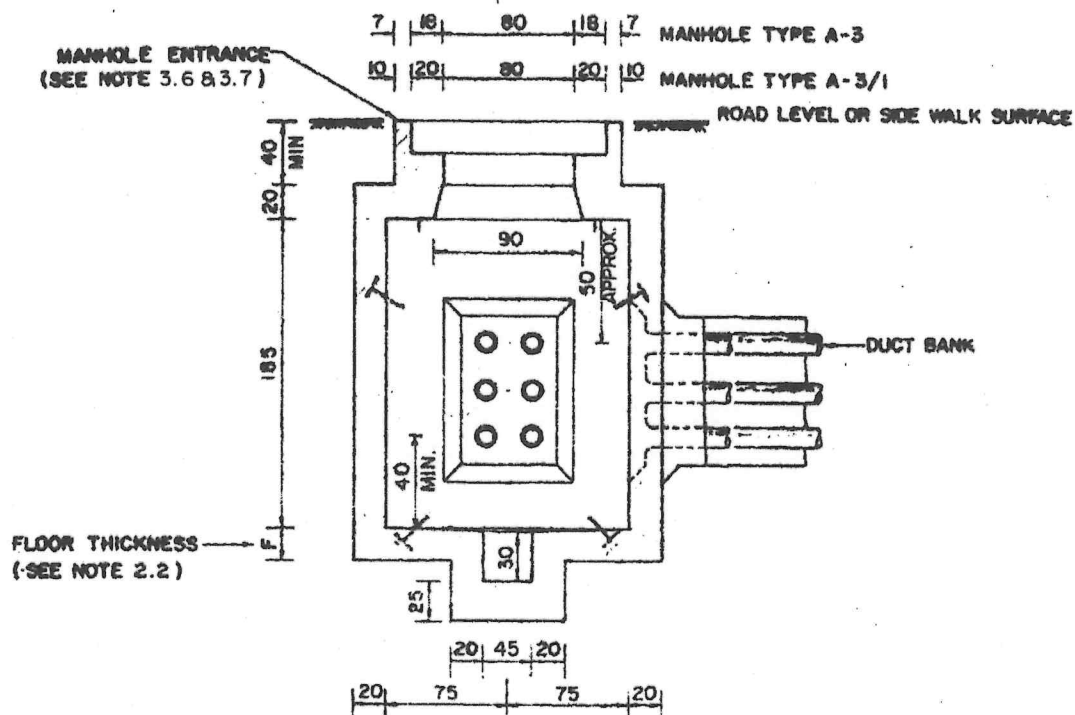

APPLICATIONS

1. MANHOLE TYPES A-3 AND A-3/I ARE SMALL-SIZED 3-WAY MANHOLES THAT ARE GENERALLY USED FOR 12 OR 24 KV. UNDERGROUND CONSTRUCTION INSIDE AND OUTSIDE NETWORK AREA.
2. MANHOLE TYPE A-3/I IS DEVELOPED FROM MANHOLE TYPE A-3 AND CAN BE CONSTRUCTED AT LOCATION WHERE IT IS SUBJECTED TO 18 TONS MAX. TRUCK LOAD.

2	CHANGED SIZE OF SUMP & POSITION OF HOOK AND REVISED WORDING	Hospital	5/11/55
1	CHANGED POSITION OF PULLING IRON AND DRIVE HOOK	Revised	7/9/32
REV. NO.	DESCRIPTION OF REVISIONS	BY	DATE
DR. Asst. Chk. Sumbat	METROPOLITAN ELECTRICITY AUTHORITY	SCALE	NONE
CH. CHIEF Sumbat B.	MANHOLE TYPE A-3 AND A-3/I	SUPERSEDING	2405
CH. CHIEF T.H.	FOR	SH. NO.	2 OF 3
CH. CHIEF B. Sumbat	12/24 KV. UNDERGROUND CONSTRUCTION.	DWG. NO.	UG-2-012
DATE	31/3/2530		

Handwritten signature and initials

NOTES.

1. DIMENSIONS ARE IN cm
2. THE MAIN DIFFERENCES OF MANHOLE TYPE A-3 AND A-3/I ARE SHOWN IN THE TABLE BELOW:

NO.	DESCRIPTION	DIFFERENCES OF MANHOLE	
		TYPE A-3	TYPE A-3/I
2.1	REFERENCE DWG. NO.	08D-001,002	08D-003/1
2.2	FLOOR THICKNESS (F),CM	23	20
2.3	NO. AND SIZE OF PILES	15-Ø5"x5M.	15-Ø6"x3M.
2.4	CAN BE SUBJECTED TO TRUCK	NO.	YES
	LOAD (18 TONS MAX. LOAD)		


3. REFERENCE DWG. NO

NO.	DESCRIPTION	DWG.NO.
3.1	GROUND LOOP IN MANHOLE	UG-10-005
3.2	PULLING IRON AND ENTRANCE STEP	UG-2-210
3.3	CABLE RACK GROUNDING	UG-10-007
3.4	CABLE RACK AND ACCESSORIES	UG-2-220
3.5	CABLE RACK MOUNTING LOCATIONS	UG-2-100
3.6	MANHOLE FRAME AND MANHOLE COVER	UG-2-240
3.7	MANHOLE ENTRANCE REINFORCEMENT	UG-2-260

1	REVISED NOTE 3.	Revised	5/11/55
REV.NO.	DESCRIPTION OF REVISIONS	BY	DATE
DR. <i>[Signature]</i>	CHK. <i>[Signature]</i> METROPOLITAN ELECTRICITY AUTHORITY		
DR. CHIEF <i>[Signature]</i> B.	MANHOLE TYPE A-3 AND A-3/I	SCALE	
EXC. MR. T.H.	FOR	SUP. ORDERING 2405	
DTY. GEN. MR. <i>[Signature]</i>	12/24 KV. UNDERGROUND CONSTRUCTION	SH. NO. 3 OF 3	
DATE 31/3/2530		FWG. UG-2-012	


[Signature]
[Signature]
[Signature]

PULLING IRON (SEE NOTE 2.3)
SHALL BE IN LINE WITH OPPOSITE
DUCT BANK CENTER LINE

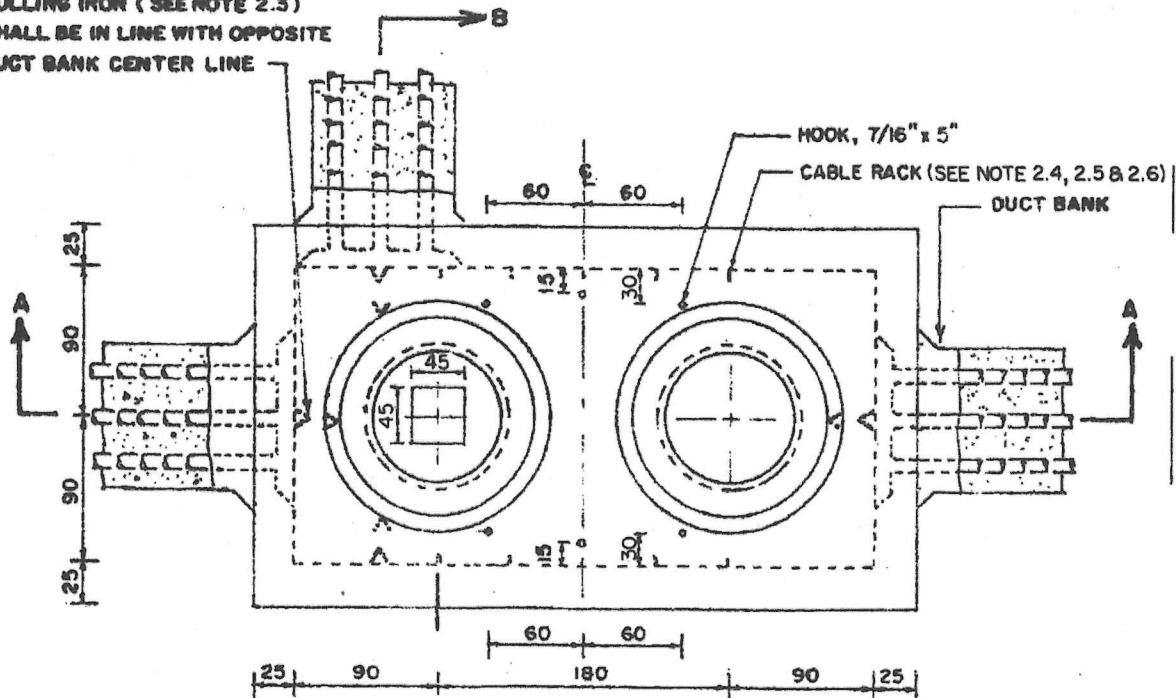

PLAN

MANHOLE ENTRANCE
(SEE NOTE 2.7 & 2.8)

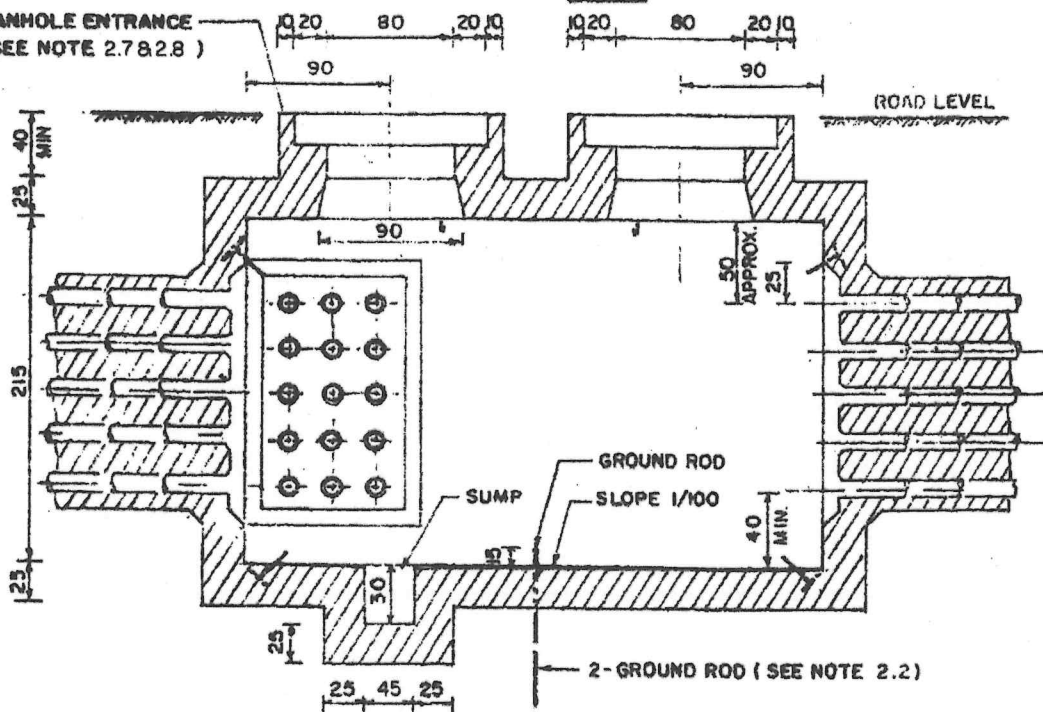

SECTION A-A

2	CHANGED SIZE OF SUMP & POSITION OF HOOK AND REVISED WORDING	Month	5/11/55
1	CHANGED POSITION OF PULLING IRON, DRIVE HOOK AND ADDED DUCT BANK	Month	7/9/32
REV. NO.	DESCRIPTION OF REVISIONS	BY	DATE
DR. GARY	CHK. S. B.	METROPOLITAN ELECTRICITY AUTHORITY	
DIV. CHIEF	TH.	SCALE NONE	
EXC. MGR.	DTY. GEN. MGR. B. J. M.	SUPERSEDING	
DATE	31/3/2530	SH. NO. 1 OF 3	
12/24 KV. UNDERGROUND CONSTRUCTION		SVG NO. UG-2-014	

Handwritten signatures and initials.



MANHOLE TYPE A-1/2 IS LARGE-SIZED 2-ENTRANCE 3-WAY MANHOLE THAT IS GENERALLY USED FOR 12 OR 24 KV. UNDERGROUND CONSTRUCTION AND CAN BE CONSTRUCTED AT LOCATION WHERE IT IS SUBJECTED TO 18 TONS MAX. TRUCK LOAD.

2 Kim Hwa



NOTES

1. DIMENSIONS ARE IN cm
2. REFERENCE DWG. NO.

NO.	DESCRIPTION	DWG.NO.
2.1	MANHOLE TYPE A-1/2	08A1-197
2.2	GROUND LOOP IN MANHOLE	UG-10-005
2.3	PULLING IRON AND ENTRANCE STEP	UG-2-210
2.4	CABLE RACK GROUNDING	UG-10-007
2.5	CABLE RACK AND ACCESSORIES	UG-2-220
2.6	CABLE RACK MOUNTING LOCATIONS	UG-2-100
2.7	MANHOLE FRAME AND MANHOLE COVER	UG-2-250
2.8	MANHOLE ENTRANCE REINFORCEMENT	UG-2-270

1	REVISED NOTE 2	5/11/55
REV. NO.	DESCRIPTION OF REVISIONS	BY DATE
DR. <i>[Signature]</i>	CHK. <i>[Signature]</i> METROPOLITAN ELECTRICITY AUTHORITY	SCALE NONE
DIV. CHIEF <i>[Signature]</i>	MANHOLE TYPE A-1/2	SUPERSEDING
EXC. MGR. T.H.	FOR	SH. NO. 3 OF 3
DTY. GEN. MGR. <i>[Signature]</i>	12/24 KV. UNDERGROUND CONSTRUCTION	DWG NO. UG-2-014
DATE 31/3/2530		

[Signature]
[Signature]
[Signature]

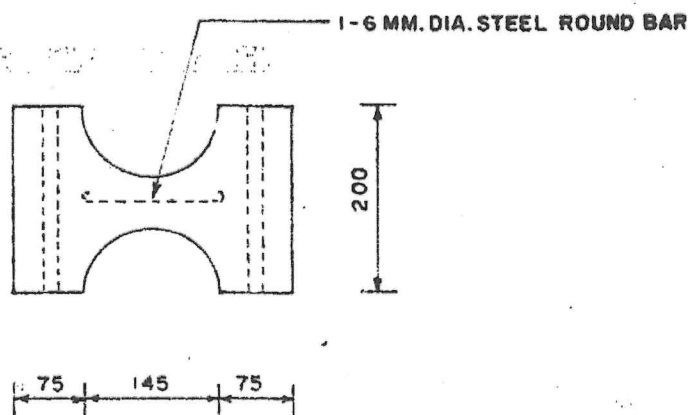
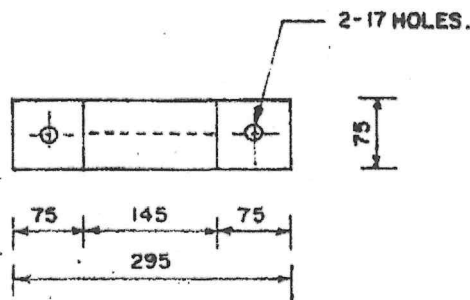


SPACER BLOCK
(FOR 1 DUCT)



NOTES 1. DIMENSIONS ARE IN MM.

2. APPLICATION : SEE DWG. NO. UG-3-100.

REV. NO.	DESCRIPTION OF REVISIONS			BY	DATE
DR. <i>Sury</i>	CHK. <i>Sambal</i>	METROPOLITAN ELECTRICITY AUTHORITY			SCALE 1:75
DIV. CHIEF		CONCRETE SPACER BLOCK (FOR Ø 140 MM. HDPE CONDUIT)			SUPERSEDING
EXC. MGR.					SH. NO. 2 OF 3
DTY. GEN. MGR.					DWG. NO. UG-8-002
DATE	25/30				

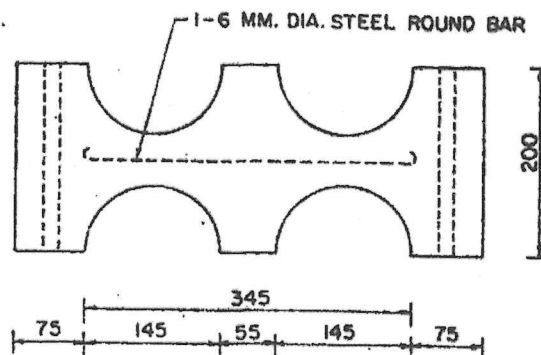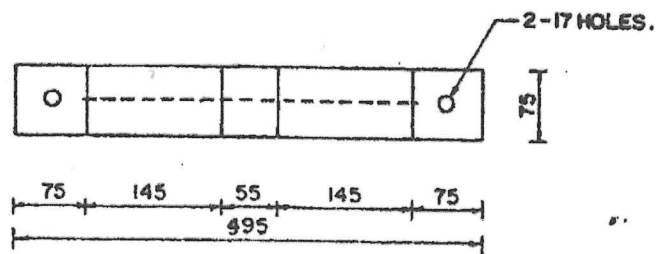


SPACER BLOCK
(FOR 2 DUCTS)

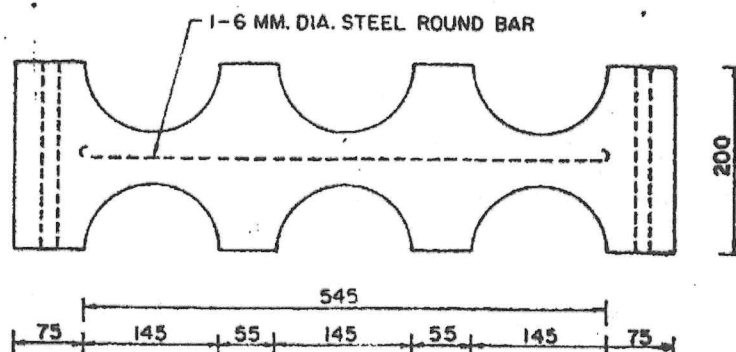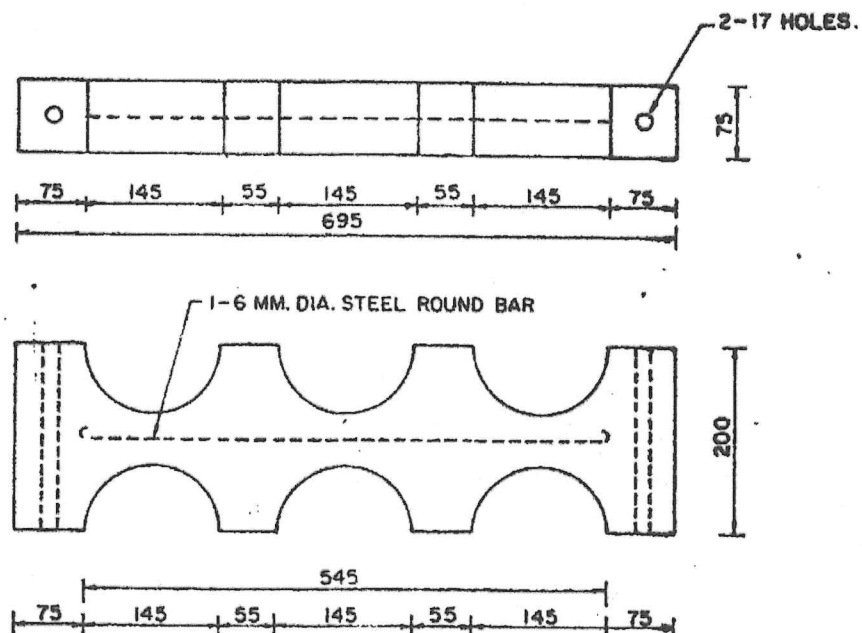

SPACER BLOCK


- NOTES**
1. DIMENSIONS ARE IN MM. (FOR 3 DUCTS)
 2. APPLICATION : SEE DWG. NO. UG-3-100

REV. NO.	DESCRIPTION OF REVISIONS			BY	DATE
DR. <i>[Signature]</i>	CHK. <i>Sombaf.</i>	METROPOLITAN ELECTRICITY AUTHORITY			SCALE 1:75
DIV. CHIEF	CONCRETE SPACER BLOCK (FOR Ø 140 MM. HDPE CONDUIT)			SUPERSEDING	
EXC. MGR.				SH. NO. 3 OF 3	
DTY. GEN. MGR.				DWG NO. UG-8-002	
DATE .2530					

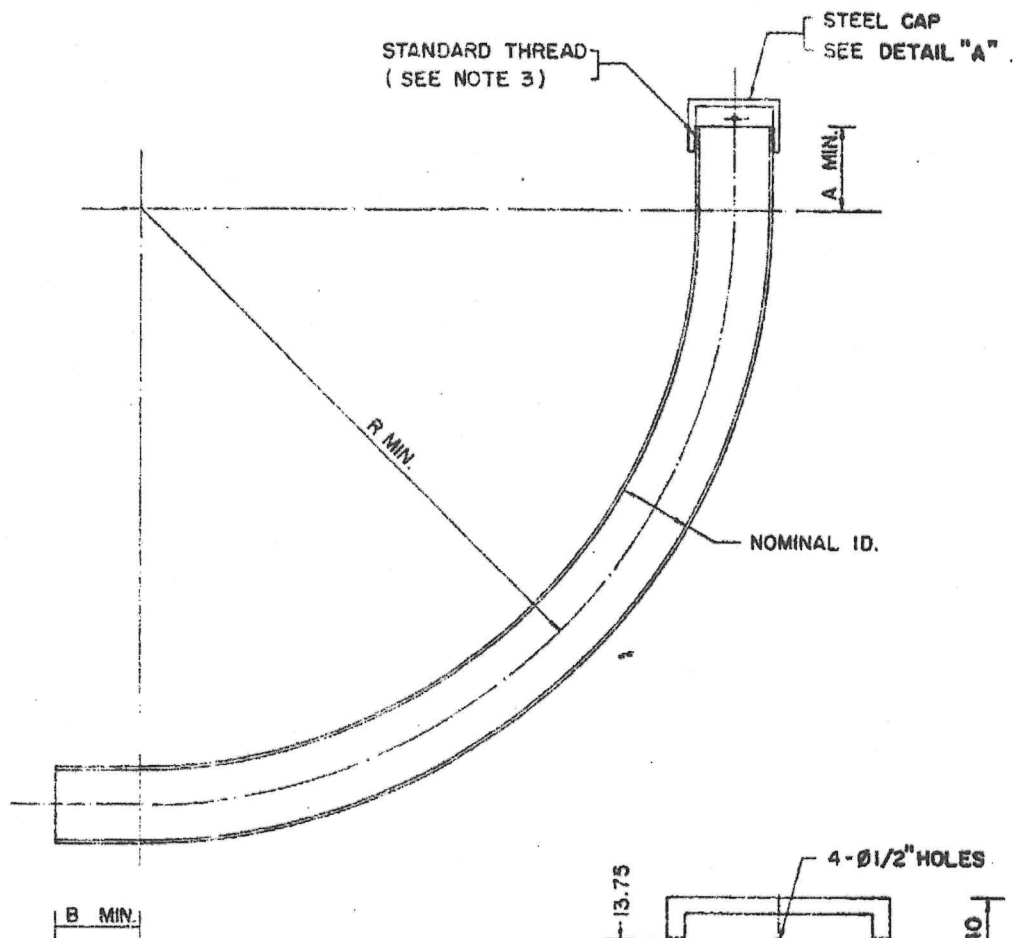

90° ELBOW, GALV. STEEL CONDUIT
(WITH GALV. STEEL CAP)

CODE NO.	NOMINAL ID.		R	A	B
	MM.	IN.			
562-400	100	4	1270	150	150
562-500	127	5	1395	300	300
562-600	150	6	1365	300	300

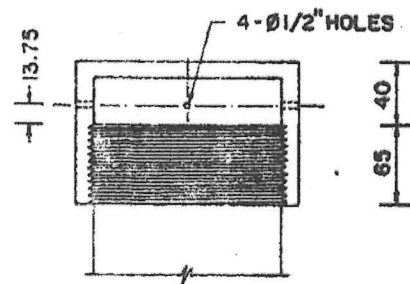


DETAIL "A"
GALV. STEEL CAP

NOTES:

1. DIMENSIONS ARE IN MM.
2. THIS TYPE OF 90° ELBOW IS APPLIED FOR 12/24 KV. CABLE RISER CONSTRUCTION.
3. STANDARD THREAD IS REFERRED TO TIS. 281-2521

REV. NO.	DESCRIPTION OF REVISIONS			BY	DATE
DR. <i>Apichet</i>	CHK. <i>Bombard</i>	METROPOLITAN ELECTRICITY AUTHORITY			SCALE 1:12.5
DIV. CHIEF <i>Sechart B.</i>	90° ELBOW (GALVANIZED STEEL CONDUIT)			SUPERSEDING 2410	
EXC. MGR. <i>T.H.</i>				SH. NO. 1 OF 3	
DTY. GEN. MGR. <i>Banyan</i>				DWG. NO. UG-8-004	
DATE 14/5/2530					

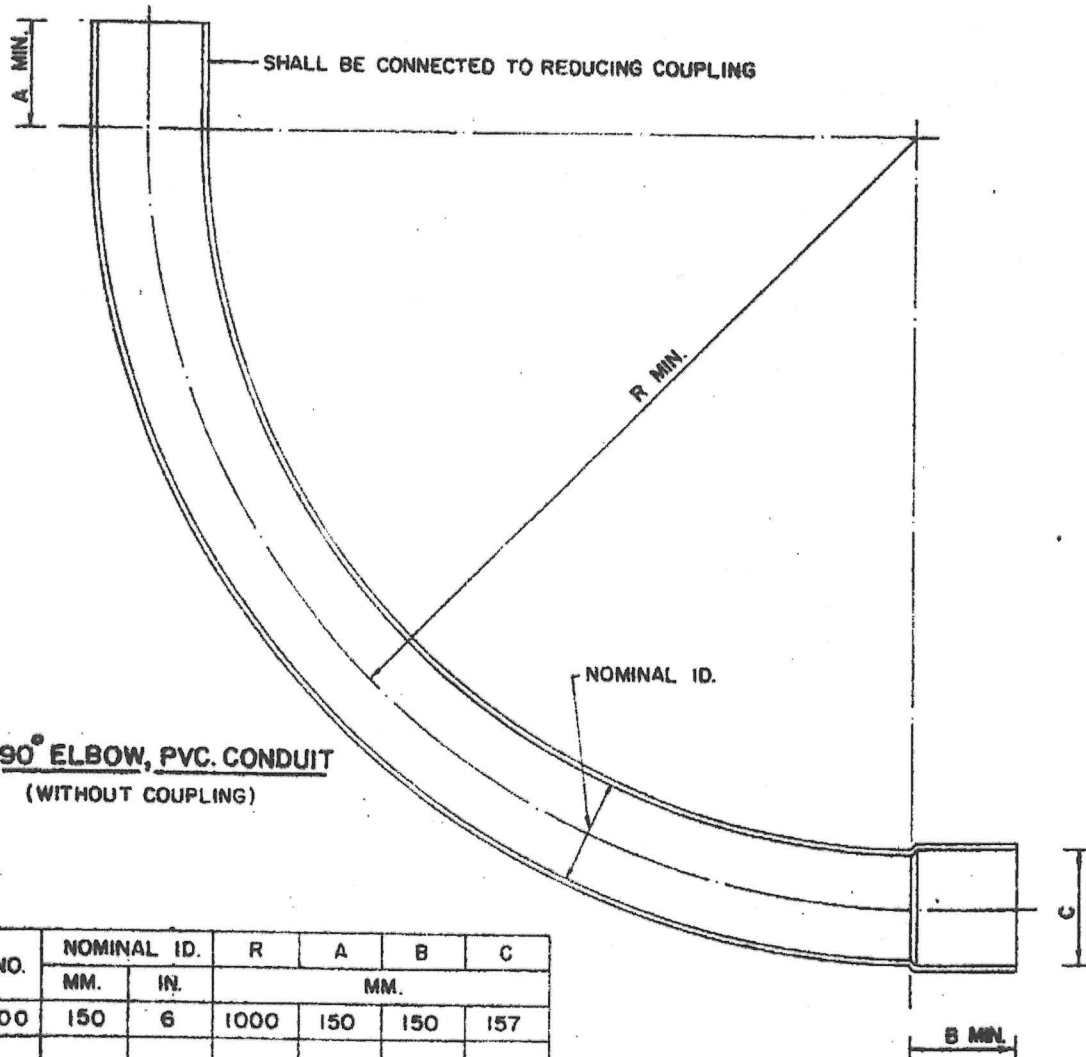


CODE NO.	NOMINAL ID.		R	A	B	C
	MM.	IN.				
503-600	150	6	1000	150	150	157

NOTE.

THIS TYPE OF 90° ELBOW IS APPLIED FOR 69 KV. CABLE RISER CONSTRUCTION.

REV. NO.	DESCRIPTION OF REVISIONS				BY	DATE
DR. <i>Apichart</i>	CHK. <i>Sombhat</i>	METROPOLITAN ELECTRICITY AUTHORITY			SCALE	1:10
DIV. CHIEF <i>Suechart B.</i>	90° ELBOW (PVC. CONDUIT)			SUPERSEDING 2410		
EXC. MGR. <i>T.H.</i>				SH. NO. 2 OF 3		
DTY. GEN. MGR. <i>Bongrid</i>				DWG. NO. UG-8-004		
DATE 14/5/2530						


Dr. Apichart

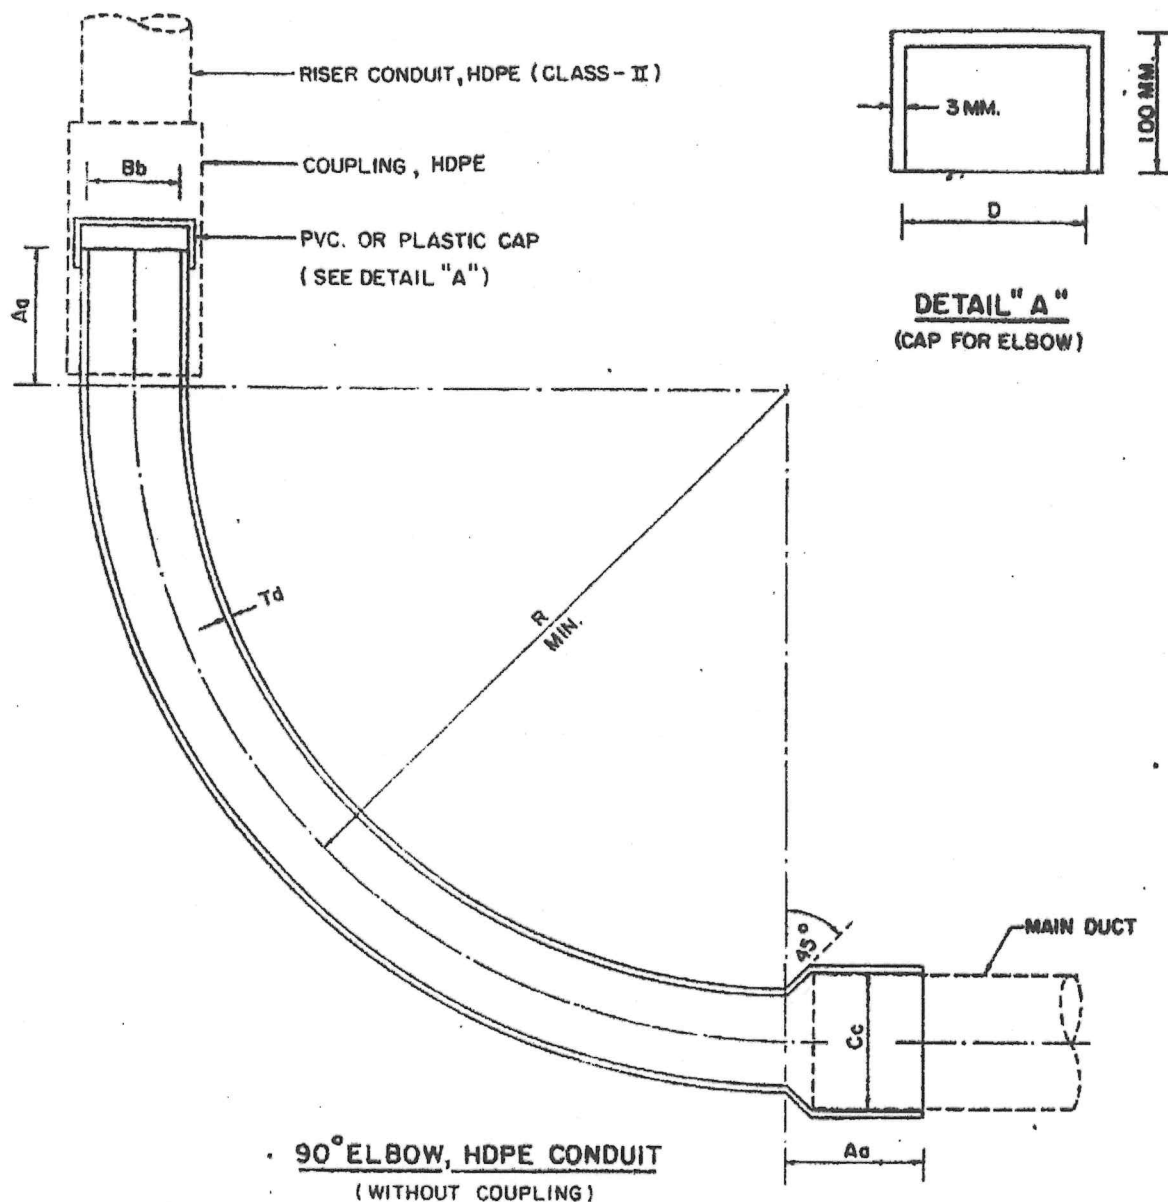

MAIN DUCT		90° ELBOW, HDPE			DIMENSION (MM.)					
SIZE (MM.)	TYPE	NOM. DIA. (MM.)	CODE NO.	TYPE	A	B	C	D	R	T
115 ID.	ASBESTOS	125	493-115	A	200	115.4	128.5	126	1000	4.8
140 ID.		140	493-140	B	200	129.2	155.5	141	1000	5.4
140 ID.		160	493-160	E	250	147.6	155.5	161	1840	6.2
125 OD.	HDPE	125	494-125	C	200	115.4	126	126	1000	4.8
140 OD.		140	494-140	D	200	129.2	141	141	1000	5.4
160 OD.		160	494-160	F	250	147.6	161	161	1840	6.2

NOTE. ALLOWABLE VARIATIONS: a = ± 5.0 MM. b = ± 1.0 MM. c = ± 1.0 MM. d = ± 0.5 MM.

3	ADDED CAP FOR ELBOW AND ADDED ELBOW TYPE E & F.			Sombat.	18/2/30
2	ADDED CODE NO. OF 90° ELBOW			Sombat.	7/10/29
1	CHANGED DWG. NO. FROM 10A4-0195 TO BE UG-8-004 AND ADDED VARIATIONS.			Sombat.	6/2/29
REV. NO.	DESCRIPTION OF REVISIONS			BY	DATE
DR. <i>[Signature]</i>	CHK. <i>Sombat.</i>	METROPOLITAN ELECTRICITY AUTHORITY		SCALE NONE	
DIV. CHIEF <i>Suehrit</i>	90° ELBOW (HDPE CONDUIT)		SUPERSEDING		
EXC. MGR. <i>Tongyay</i>			SH. NO. 3 OF 3		
DTY. GEN. MGR. <i>An. Adan.</i>			DWG. NO. UG-8-004		
DATE 15/10/2528					

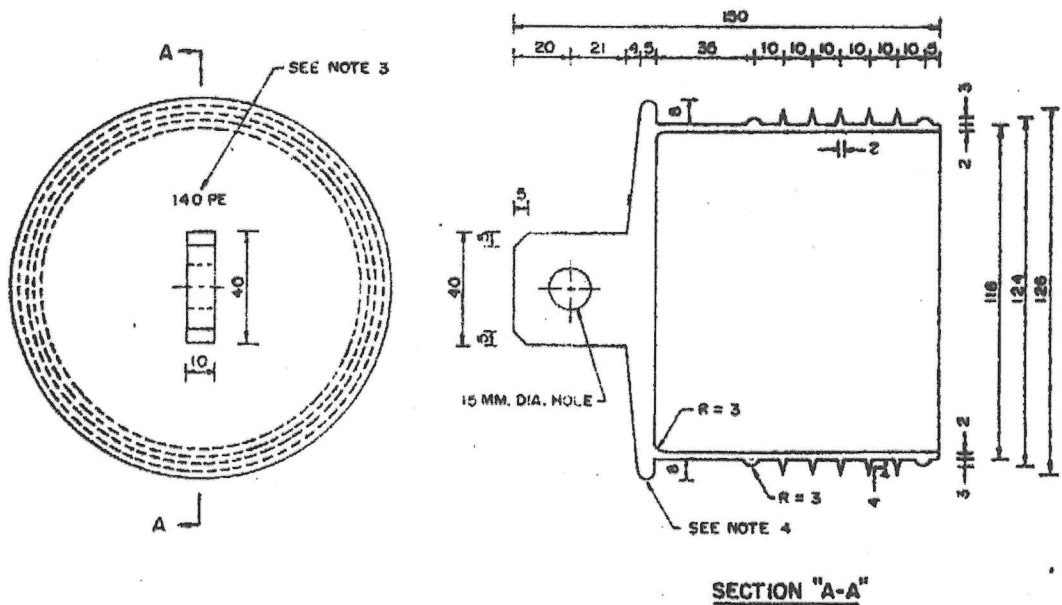


PLASTIC PLUG

NOTES

1. DIMENSIONS ARE IN MM.
2. MATERIAL: LOW DENSITY POLYETHYLENE.
3. MARKING SHOWS HDPE CONDUIT SIZE WITH WHICH THIS PLUG WILL BE APPLIED.
THE FIGURES AND LETTER ARE 1 MM. STANDING OUT OF THE SURFACE.
4. SQUARE OR ROUND EDGE IS ACCEPTABLE.

REV. NO.	DESCRIPTION OF REVISIONS			BY	DATE
DR. <i>At</i>	CHK. <i>Sombad</i>	METROPOLITAN ELECTRICITY AUTHORITY			SCALE 1:2.5
DIV. CHIEF <i>Sushant B.</i>	PLASTIC PLUG FOR Ø 140 MM. HDPE CONDUIT CLASS-I			SUPERSEDING	
EXC. MGR. <i>T.H.</i>				SH. NO. 3 OF 3	
DTY. GEN. MGR. <i>Banyan</i>				DWG NO. UG-8-005	
DATE: 14/5/2530					

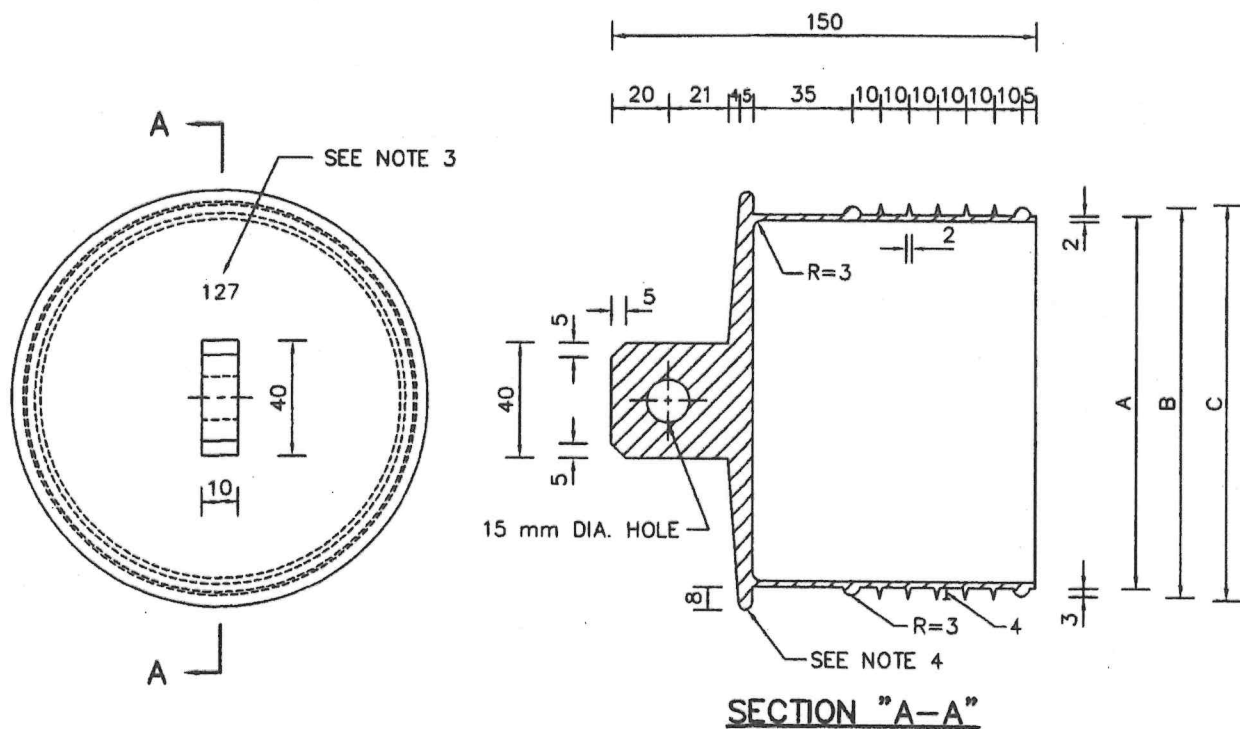


PLASTIC PLUG FOR RTRC CONDUIT

SIZE ID A INCH(mm)	A	B	C
4 (101.6)	95	101	103
5 (127)	120	126	128
6 (152.40)	146	152	154

NOTES

1. DIMENSIONS ARE IN mm.
2. MATERIAL : BLACK POLYETHYLENE
3. MARKING SHOWS RTRC CONDUIT SIZE WHICH THIS PLUG WILL BE APPLIED. THE FIGURES AND LETTERS ARE 1 mm. STANDING OUT OF THE SURFACE
4. SQUARE OR ROUND EDGE IS ACCEPTABLE.
5. REFERENCE CONDUIT FOR RTRC : ท่ออีพ็อกซีเรซินเสริมใยแก้วสำหรับใช้ร้อยสายไฟฟ้า และสายโทรศัพท์ ชนิด BG ชั้นคุณภาพที่ 1 ตาม มอก. 2518-2556 หรือฉบับล่าสุด

REV.NO.	DESCRIPTION OF REVISIONS				BY	DATE
DR. <i>Gintasil</i>	ENGR. <i>Gintasil</i>	METROPOLITAN ELECTRICITY AUTHORITY			SCALE	NONE
CHF.SEC. <i>Monthol (coating)</i>	ACCESSORIES FOR RTRC CONDUIT (PLASTIC PLUG)			SUPERSEDING 10A4-0404		
CHK. <i>-</i>				SH.NO. 1 OF 2		
DIR.DIV. <i>Pongsan</i>				DWG. 10A4-0734		
DATE 22/5/2556				NO.		

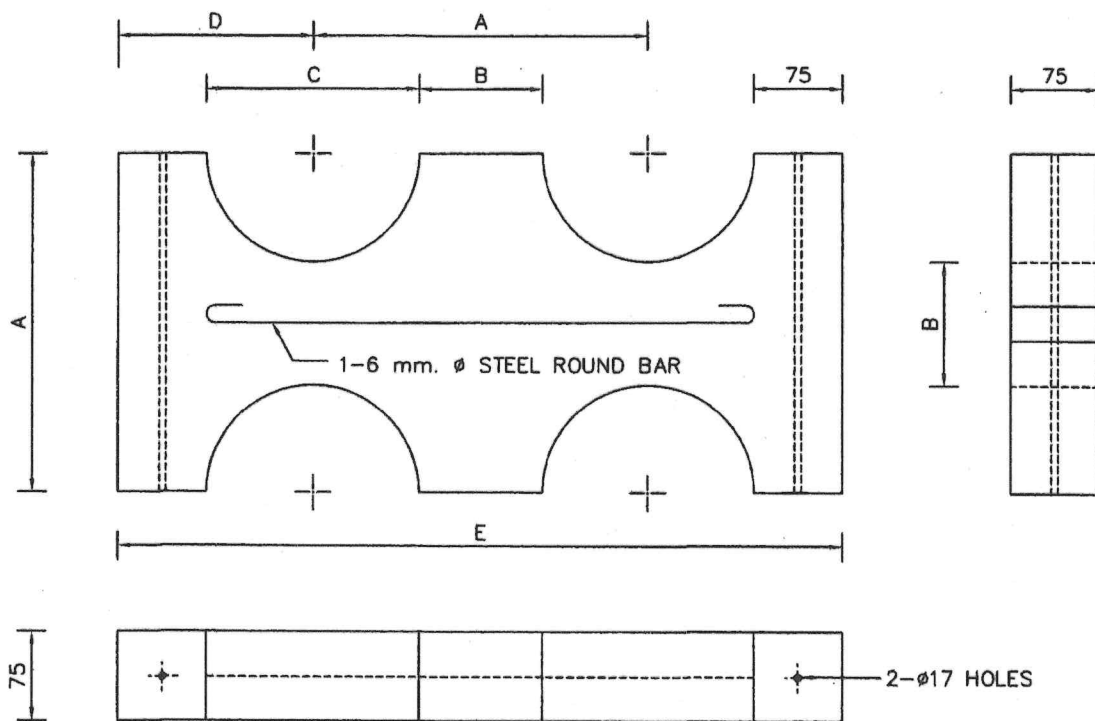

TYPICAL CONCRETE SPACER BLOCK FOR RTRC CONDUIT

(2 DUCT)


SPACER BLOCK TABLE

DIA. OF DUCT (mm)	A	B	C	D	E
100	190	78	112	131	452
125	250	112	138	144	538
150	250	86	164	157	564

NOTE DIMENSIONS ARE IN mm UNLESS OTHERWISE SPECIFIED


REV.NO.	DESCRIPTION OF REVISIONS	BY	DATE
DR. <i>Gintasil</i>	ENGR. <i>Gintasil</i>	METROPOLITAN ELECTRICITY AUTHORITY	SCALE NONE
CHF. SEC. <i>Monthol</i> (acting)	ACCESSORIES FOR RTRC CONDUIT (CONCRETE SPACER BLOCK)	SUPERSEDING 10A4-0404	
CHK. -		SH.NO. 2 OF 2	
DIR. DIV. <i>Pongsan</i>		DWG. NO. 10A4-0734	
DATE 22/5/2556			

Handwritten signatures and initials.

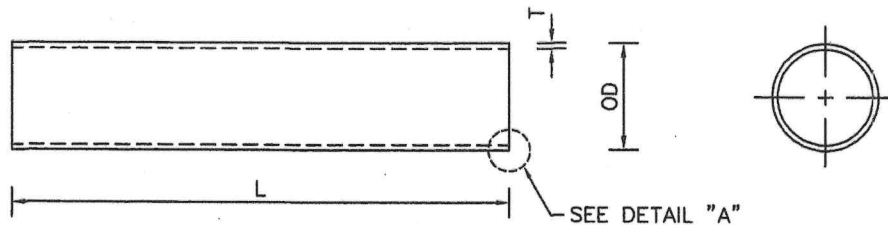

HIGH DENSITY POLYETHYLENE CONDUIT

SIZE DESIGNATION (mm)	AVERAGE OD (mm)		L (mm)	HDPE CONDUIT CLASS-I			HDPE CONDUIT CLASS-II		
				T (mm)		MASS ²⁾ (kg/m)	T (mm)		MASS ²⁾ (kg/m)
	MIN.	MAX.		MIN.	MAX.		MIN.	MAX.	
50	50.0	50.4	6000 ⁺⁶⁰ ₀	3.0	3.4	0.453	2.0	2.3	0.314
63	63.0	63.4	6000 ⁺⁶⁰ ₀	3.8	4.3	0.721	2.5	2.9	0.494
75	75.0	75.5	6000 ⁺⁶⁰ ₀	4.5	5.1	1.02	2.9	3.3	0.675
90	90.0	90.6	6000 ⁺⁶⁰ ₀	5.4	6.1	1.46	3.5	4.0	0.978
110	110.0	110.7	6000 ⁺⁶⁰ ₀	6.6	7.4	2.17	4.2	4.8	1.43
125	125.0	125.8	6000 ⁺⁶⁰ ₀	7.4	8.3	2.76	4.8	5.4	1.84
140	140.0	140.9	6000 ⁺⁶⁰ ₀	8.3	9.3	3.46	5.4	6.1	2.32
160	160.0	161.0	6000 ⁺⁶⁰ ₀	9.5	10.6	4.52	6.2	7.0	3.04

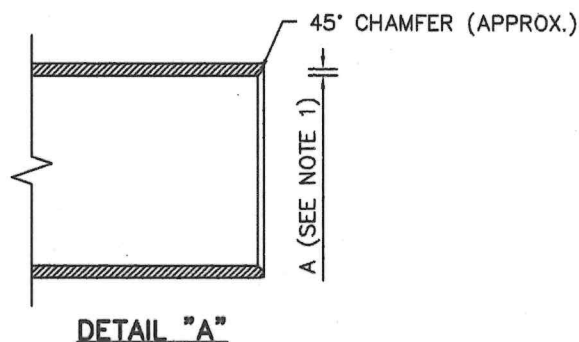

NOTES

1. DIMENSION A IS EQUAL TO T/2 APPROXIMATELY.
2. THE MASS HAS BEEN CALCULATED TAKING THE AVERAGE DENSITY AS 0.95 g/cm³.

APPLICATIONS

1. HDPE CONDUIT CLASS-I SHALL BE USED TO BE MAIN DUCT.
2. HDPE CONDUIT CLASS-II SHALL BE USED TO BE 90° ELBOW AND CONDUIT INSTALLED ABOVE GROUND.

2	REVISED DIMENSIONS OF HDPE CONDUIT AND NOTE					28/10/65
1	REVISED DIMENSIONS OF HDPE CONDUIT AND NOTE					Month/ 11/5/58
REV. NO.	DESCRIPTION OF REVISIONS					BY DATE
DR. <i>[Signature]</i>	CHK <i>[Signature]</i>	METROPOLITAN ELECTRICITY AUTHORITY				SCALE NONE
DIV. CHIEF	HIGH DENSITY POLYETHYLENE CONDUIT (HDPE CONDUIT)				SUPERSEDING	
EXC. MGR.					SH. NO. 1 OF 2	
DTY. GEN. MGR.					DWS	
DATE . 2530					NO. UG-8-008	

[Signature]

HIGH DENSITY POLYETHYLENE CONDUIT

SIZE DESIGNATION (mm)	HDPE CONDUIT CLASS-I	HDPE CONDUIT CLASS-II
	CODE NO.	CODE NO.
50	4730-490-05000	4730-490-05010
63	4730-490-06300	4730-490-06310
75	4730-490-07500	4730-490-07510
90	4730-490-09000	4730-490-09010
110	4730-490-11000	4730-490-11010
125	4730-490-12500	4730-490-12510
140	4730-490-14000	4730-490-14010
160	4730-490-16000	4730-490-16010

I	REVISED CODE NO. AND CHANGED FROM 6 TO 12 DIGITS.	W/H/Ext.	22/3/36
REV.NO.	DESCRIPTION OF REVISIONS	BY	DATE
DR. <i>Choochert</i>	METROPOLITAN ELECTRICITY AUTHORITY HIGH DENSITY POLYETHYLENE CONDUIT (HDPE CONDUIT)	SCALE NONE	
CHK. <i>W/H/Ext</i>		SUPERSEDING	
DIR.DIV.		SH.NO. 2 OF 2	
DIR.DEPT.		DWG. NO. UG-8-008	
DEP.DIV.			
DATE			

W/H/Ext

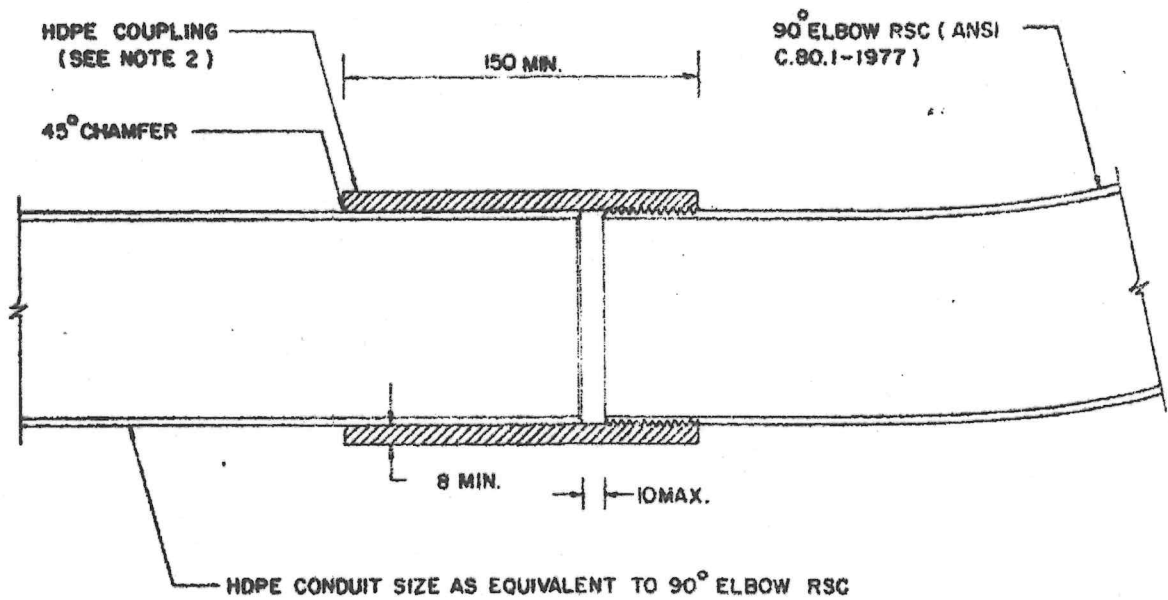


FIG.1 HDPE COUPLING (HDPE-RSC)


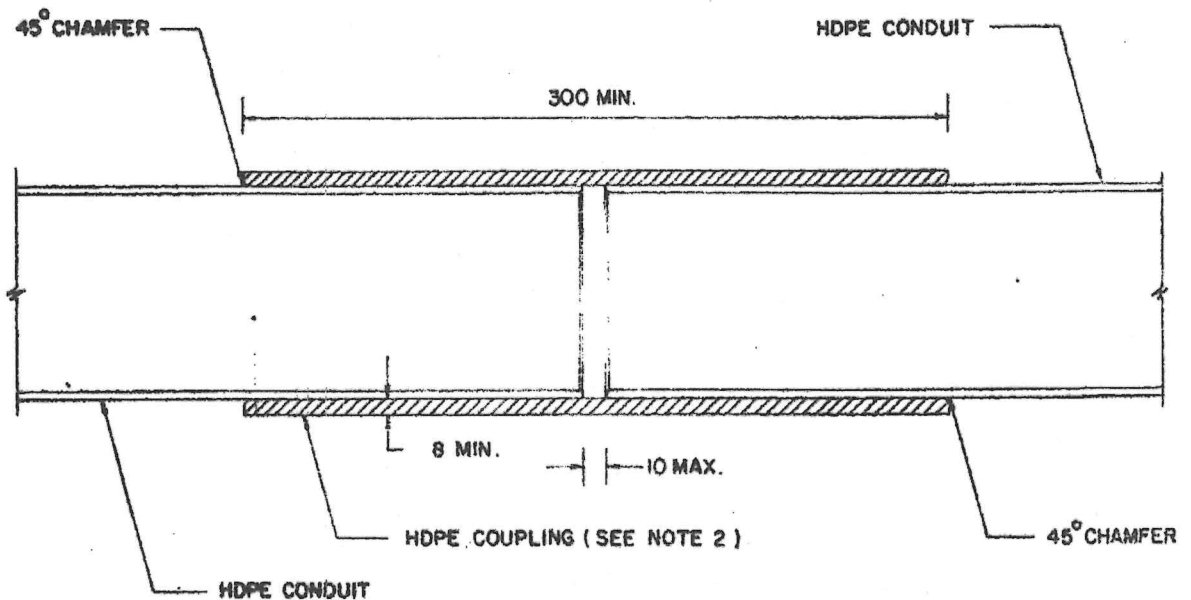


FIG.2 HDPE COUPLING (HDPE-HDPE)

- NOTES.**
1. DIMENSIONS ARE IN MM.
 2. HDPE COUPLING SHALL BE MADE TO SUIT THE PURPOSE OF CONNECTION BETWEEN THE SPECIFIED CONDUITS.
 3. SEE DWG. NO. UG-8-008 FOR DETAILS OF HDPE CONDUIT.

REV. NO.	DESCRIPTION OF REVISIONS			BY	DATE
DR. <i>Apichant</i>	CHK. <i>Sombal</i>	METROPOLITAN ELECTRICITY AUTHORITY			SCALE 1:3
DIV. CHIEF	HDPE COUPLING (HDPE-RSC AND HDPE-HDPE)			SUPERSEDING	
EXC. MGR.				SH. NO. 1 OF 1	
DTY. GEN. MGR.				DWG. NO. UG-8-010	
DATE . 2530					

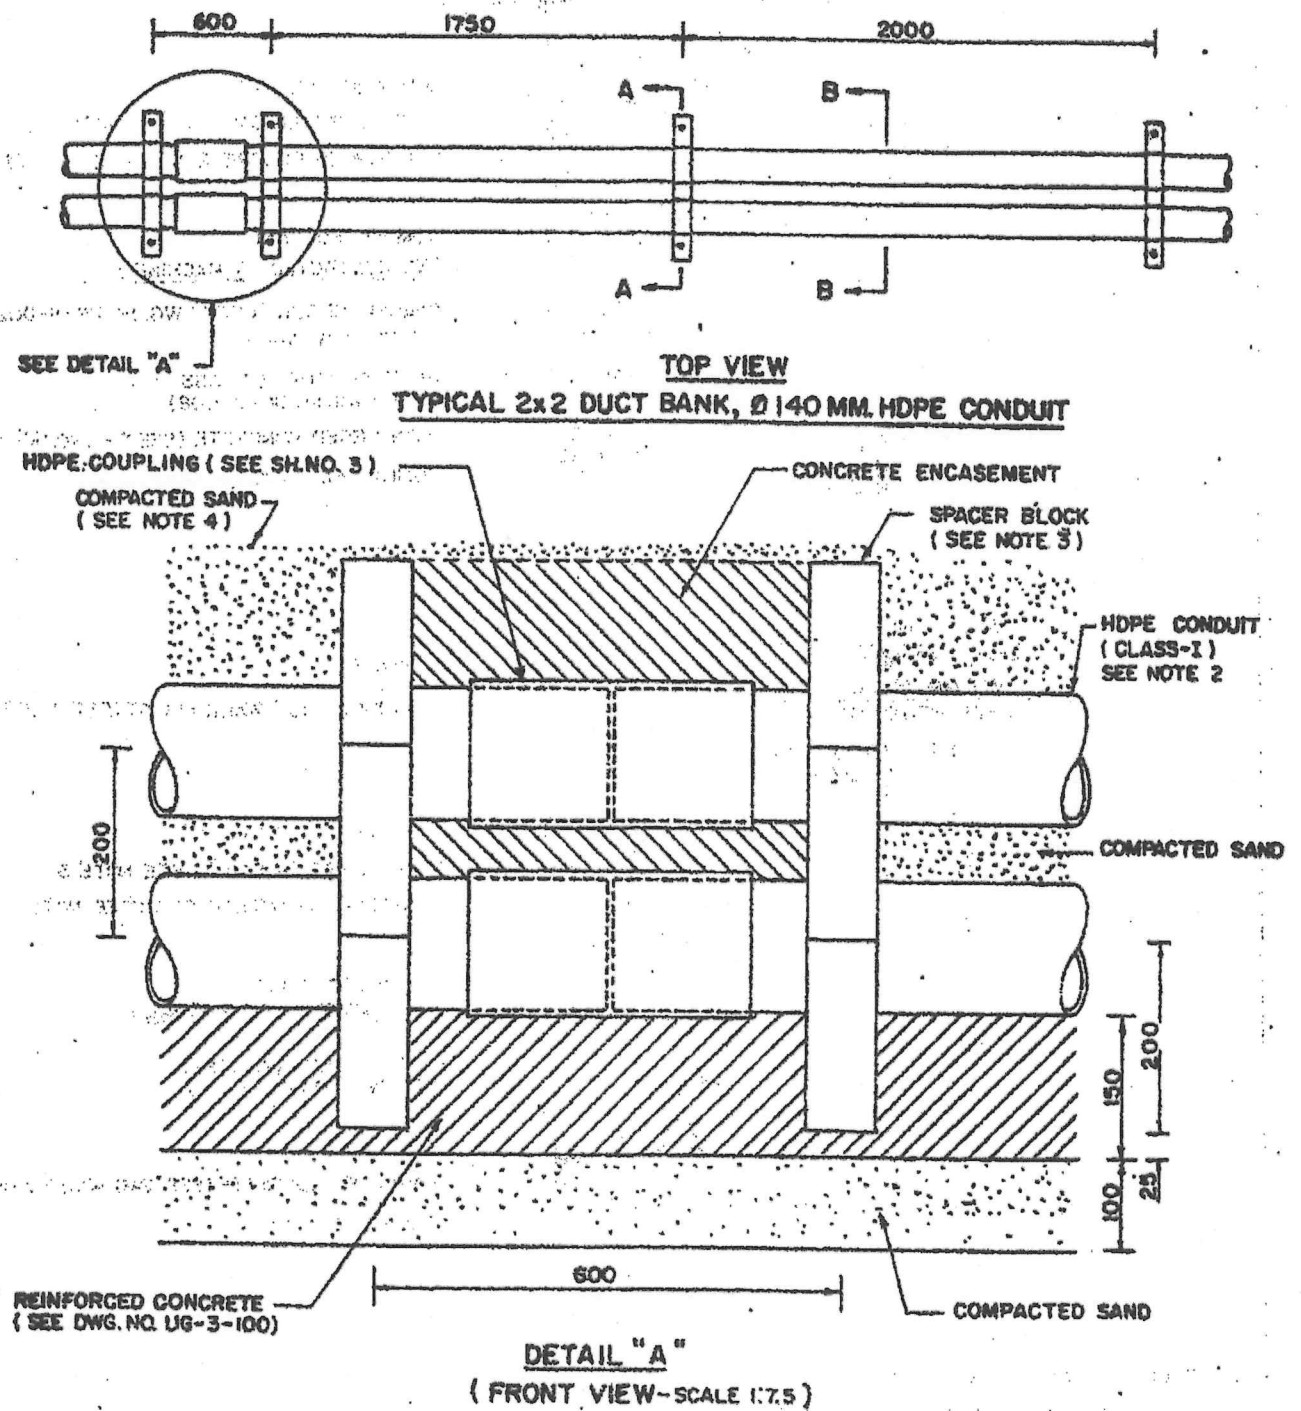



NOTES 1. DIMENSIONS ARE IN MM.

2. FOR DETAILS OF HDPE CONDUIT, SEE DWG. NO. UG-8-008.

3. SEE DETAILS ON DWG. NO. UG-8-002 (SH. NO. 3) & UG-3-100.

4. NO COMPACTED BY MACHINE..

REV. NO.	DESCRIPTION OF REVISIONS				BY	DATE
DR. <i>de</i>	CHK. <i>Scmbal</i>	METROPOLITAN ELECTRICITY AUTHORITY			SCALE	1:30
DIV. CHIEF	UG. PRIMARY & SUBTRANSMISSION CONSTRUCTION HDPE DUCT BANK			SUPERSEDING		
EXC. MGR.				SH. NO. 1 OF 3		
DTY. GEN. MGR.				DWG		
DATE				2530	NO. UG-6-100	

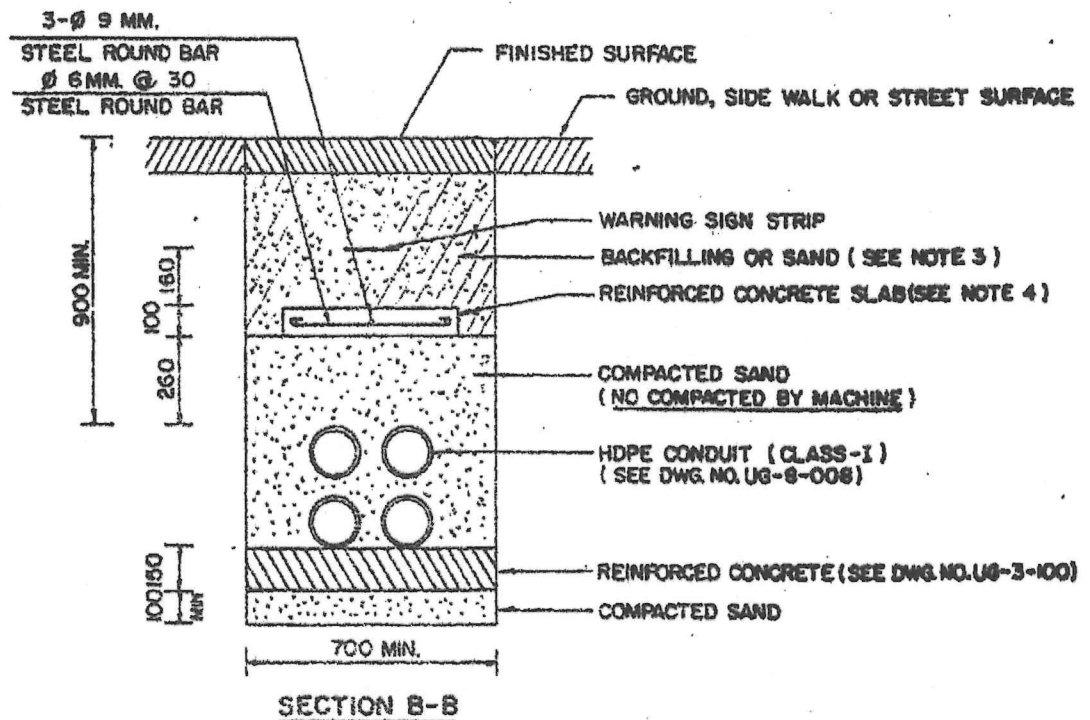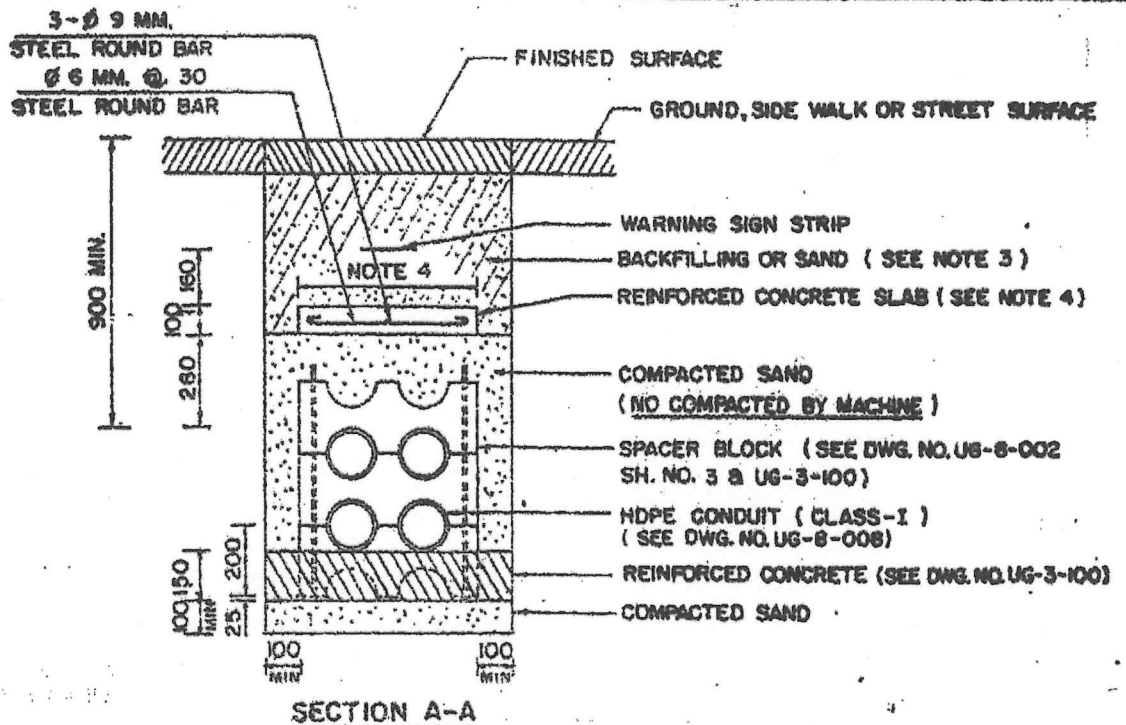


NOTES.

1. DIMENSIONS ARE IN MM.
2. FOR CIRCUIT SEQUENCE AND NO. OF UG. CABLE IN HDPE CONDUIT, SEE DWG. NO. UG-4-002 & UG-4-003.
3. BACKFILLING (OR SAND) IS COMPACTED ACCORDING TO REQUIREMENTS SET BY THE SIDE WALK OR STREET STRUCTURE.
4. THE WIDTH OF CONCRETE SLAB IS THE SAME AS OF SPACER BLOCK.

REV. NO.	DESCRIPTION OF REVISIONS			BY	DATE
OR <i>AK</i>	CHK. <i>Sambal</i>	METROPOLITAN ELECTRICITY AUTHORITY			SCALE 1:20
DIV. CHIEF		UG. PRIMARY & SUBTRANSMISSION			SUPERSEDING
EXC. MGR.		CONSTRUCTION			SH. NO. 2 OF 3
DTY. GEN. MGR.		HDPE DUCT BANK			DWG NO. UG-6-100
DATE	2030				


METHOD OF HDPE CONDUIT CONNECTION

1. MARKING

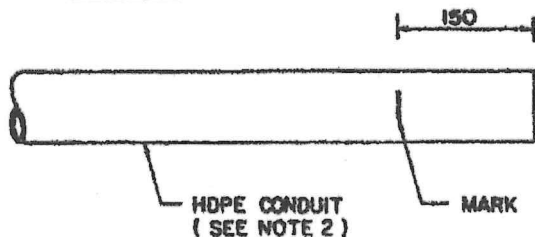


- MARK END OF CONDUIT TO BE CONNECTED.

2. CLEANING

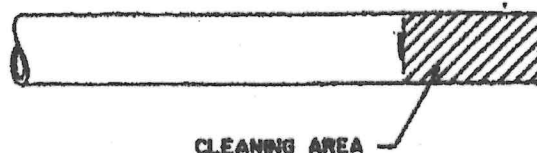


- USING DAMP CLOTH TO CLEAN OUTSIDE CONDUIT AND INSIDE OF COUPLING.

3. APPLY ADHESIVE (SEE NOTE 3)

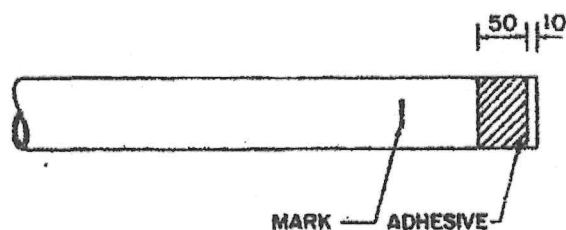


- APPLIED RUBBER ADHESIVE BY BRUSH AS SHOWN IN THE FIGURE.

4. CONNECTION

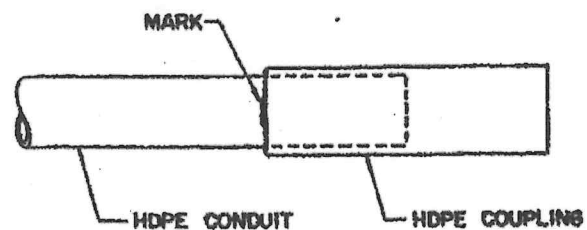

- SLIDE A CONDUIT IN TO A COUPLING.

5. COMPLETED CONNECTION

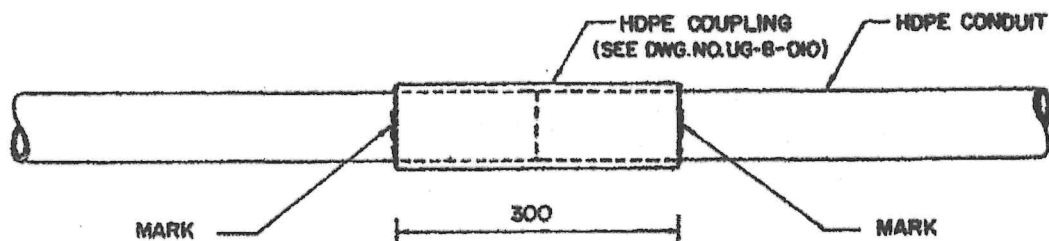

- REPEAT STEP 1 TO 3 FOR THE OTHER CONDUIT AND SLIDE A CONDUIT INTO A COUPLING UNTIL THE BOTH END OF CONDUITS ARE BUTTED.


NOTES.

1. DIMENSIONS ARE IN MM.
2. THE METHOD SHOWN ABOVE CAN BE USED FOR BOTH CLASS-I AND CLASS-II HDPE CONDUIT (SEE DETAILS OF HDPE CONDUIT ON DWG. NO. UG-8-008)
3. THE PURPOSE OF APPLYING RUBBER ADHESIVE (RUBBER CEMENT) IS TO PROTECT LEAKING OF WATER INTO CONDUIT COUPLING.

[Signature]

REV. NO.	DESCRIPTION OF REVISIONS			BY	DATE
DR. <i>[Signature]</i>	CHK. <i>[Signature]</i>	METROPOLITAN ELECTRICITY AUTHORITY			SCALE NONE
DIV. CHIEF	UG. PRIMARY & SUBTRANSMISSION CONSTRUCTION HDPE DUCT BANK			SUPERSEDING	
EXC. MGR.				SH. NO. 3 OF 3	
DTY. GEN. MGR.				DWG. NO. UG-6-100	
DATE 2530					

[Signature]

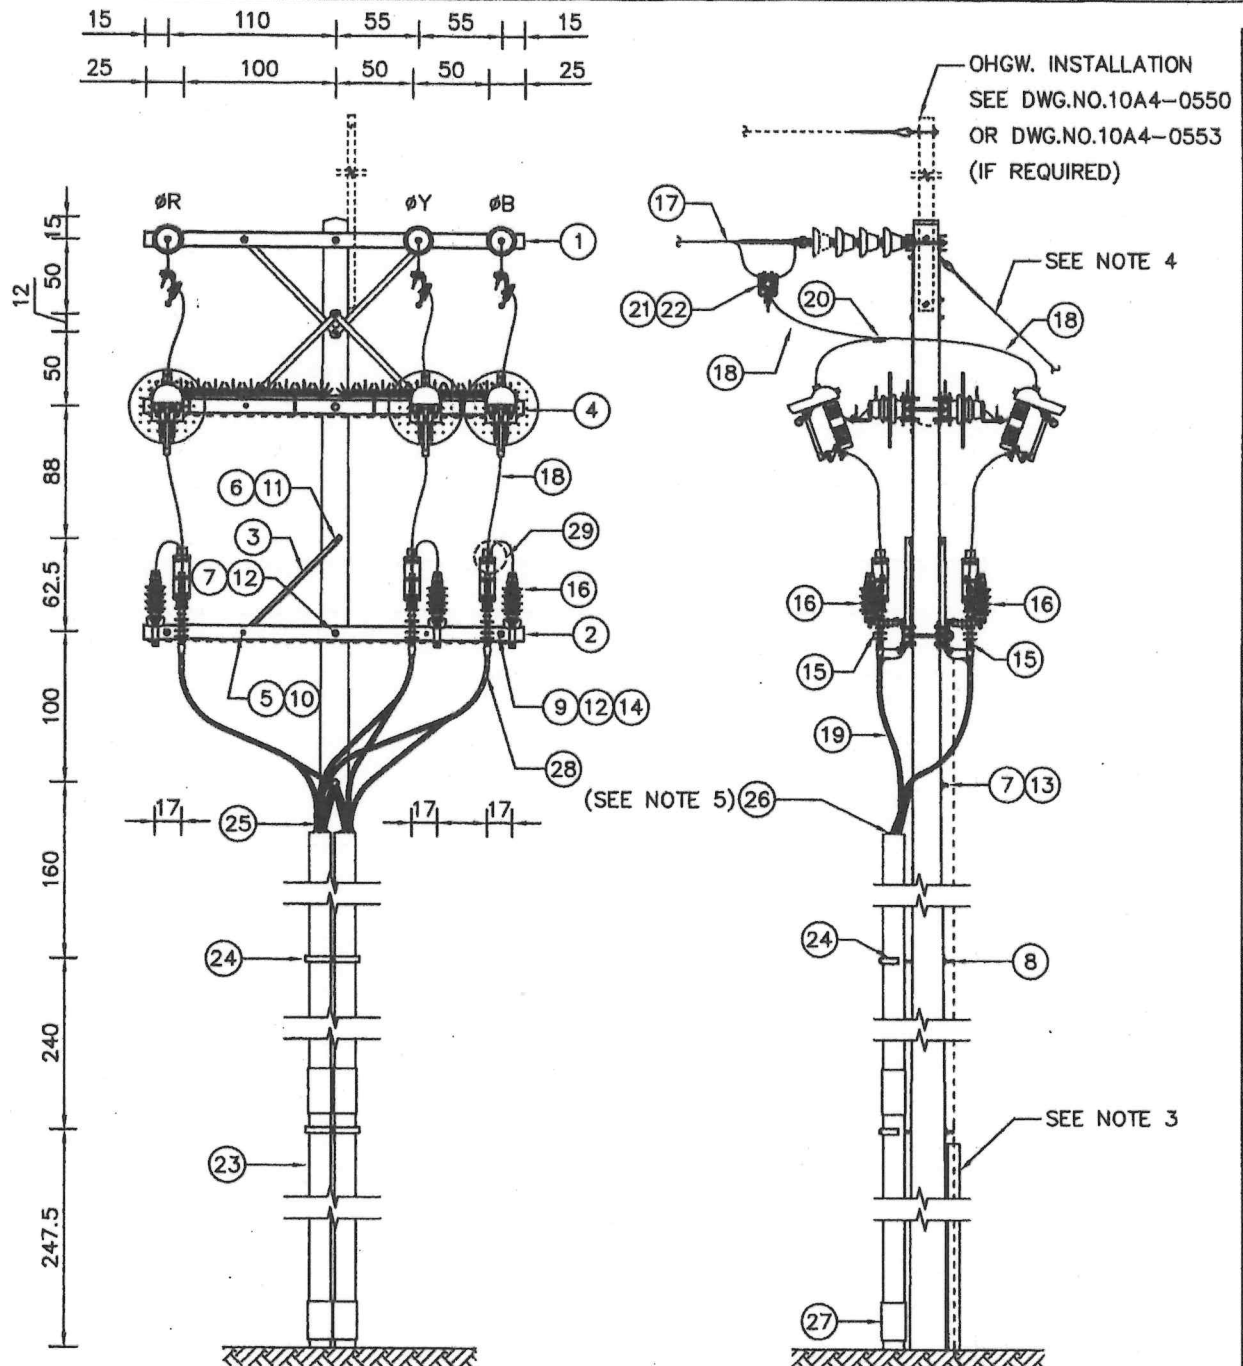

NOTES

1. DIMENSION ARE IN cm.
2. FOR SPARE CIRCUIT, THE FUSES AND FUSE HOLDERS SHALL NOT BE INSTALLED.
3. SEE GROUNDING DIAGRAM IN DWG. NO.1702 SH.NO.1 FIG. D.
4. FOR UNGUYED-POLE INSTALLATION, SPACED AERIAL CABLE 70 mm² SHELL BE STRUNG WITH STRINGING TENSION 210 N IN MAXIMUM SLACK SPAN 10 m (1 N = 0.2248 lb = 0.102 kg).
5. STUFF CONDUIT ENTRANCE WITH CORK TAPE.


1	REVISED DRAWING, NOTES, AND SCALE				Month	7/10/59
REV. NO.	DESCRIPTION OF REVISIONS				BY	DATE
DR. <i>all</i>	CHK. <i>Sambal</i>	METROPOLITAN ELECTRICITY AUTHORITY			SCALE	NONE
DIV. CHIEF <i>Sambal A</i>	12 OR 24 KV. CABLE RISER LINE ARM DEADEND CONSTRUCTION (DOUBLE CIRCUIT)			SUPERSEDING		
EXC. MGR. <i>T.H.</i>				SH. NO. 1 OF 2		
DTY. GEN. MGR. <i>Sambal</i>				DWG NO. 1409		
DATE 21/11/2529						

Sambal

BILL OF MATERIAL			
ITEM NO.	CODE NO.	REQ'D	DESCRIPTION
1	-	1	DOUBLE CROSSARM SINGLE DEADEND ASSEMBLY (DWG. NO.318 SH. NO.2 FIG.B)
2	5625-662-25200	2	CROSSARM, STEEL CHANNEL 100 x 50 x 5 mm. x 2,5 m. LONG
3	5615-030-29100	2	BRACE CROSSARM STEEL ANGLE 40 x 40 x 4 mm. x 91.3 cm. LONG
4	-	2	DROP FUSE CUTOUT INSTALLATION (SEE DWG. NO.006)
5	5605-003-01400	2	BOLT, MACHINE 3/8" x 1-1/2"
6	5605-004-41000	1	BOLT, MACHINE 1/2" x 10"
7	5605-005-51000	2	BOLT, MACHINE 5/8" x 10"
8	5605-005-51600	2	BOLT, MACHINE 5/8" x 16"
9	5605-011-51200	2	BOLT, DOUBLE ARMING OVAL EYE, 5/8" x 12"
10	5605-025-30000	2	WASHER, ROUND FOR 3/8" BOLT
11	5605-025-40000	2	WASHER, ROUND FOR 1/2" BOLT
12	5605-025-50000	6	WASHER, ROUND FOR 5/8" BOLT
13	5605-027-52200	1	WASHER, SQUARE FLAT FOR 5/8" BOLT
14	5605-022-50000	2	NUT, SQUARE FOR 5/8" BOLT
15	6145-259-07200	6	TERMINATOR, FOR CU CABLE XLPE 12/20 kV 70 mm ²
16	5920-475-20000	6	LIGHTNING ARRESTER, 9 kV 10 kA (FOR 12 kV SYSTEM) OR
	5920-474-09100		LIGHTNING ARRESTER, 21 kV 10 kA (FOR 24 kV SYSTEM)
17	6145-229-20400	AS REQ'D	SPACED AERIAL CABLE 70 mm ²
18	6145-201-07000	AS REQ'D	CONDUCTOR, PVC INSULATED MEA TYPE A 70 mm ²
19	6145-235-07100	AS REQ'D	CONDUCTOR, COPPER CABLE XLPE 12/20 kV 70 mm ²
20	6145-063-62400	3	CONNECTOR, TAP COMPRESSION (C-FRAME) 70-95 mm ² R&T
21	6145-073-14300	3	CLAMP, STIRRUP FOR 35-70 mm ²
22	6145-068-16500	3	CLAMP, HOT-LINE FOR 16-70 mm ²
23	4710-518-50000	4	CONDUIT, RIGID STEEL (RSC) Ø125mm (5")
24	4710-518-51200	2	SUPPORT BRACKET FOR CONDUIT 5" (DOUBLE)
25	6145-253-03500	2	SUPPORT GRIP 3"-3.5"
26	5970-312-23000	AS REQ'D	CORK TAPE 2" x 30 ft
27	4730-497-14000	2	COUPLING, FOR HDPE Ø140 mm-RSC Ø 5" OR
28	5970-311-62100	AS REQ'D	PVC TAPE, WHITE 3/4" x 20 m
29	-	6	TERMINAL CONNECTION ASSEMBLY (DWG.NO.10A4-0664 SH.NO.4 FIG.E)
30	5970-311-66600	1	GROUND ASSEMBLY, (SEE DWG. NO.1702 SH. NO.1 FIG.D)

2	REVISED BILL OF MATERIAL		Manthel	7/10/59	
1	REVISED CODE NO. OF ITEM NO. 21		Sombad	15/12/30	
REV. NO.	DESCRIPTION	OF	REVISIONS	BY	DATE
DR. <i>Apudat</i>	CHK. <i>Sombad</i>	METROPOLITAN ELECTRICITY AUTHORITY		SCALE	
DIV. CHIEF <i>Fuchant B.</i>	12 OR 24 KV. CABLE RISER LINE ARM DEADEND CONSTRUCTION (DOUBLE CIRCUIT)		SUPERSEDING		
EXC. MGR. <i>T.H.</i>			SH. NO. 2 OF 2		
DTY. GEN. MGR. <i>Bong...</i>			DWG NO. 1409		
DATE 21/11/2529					


S *Kim Hoon*

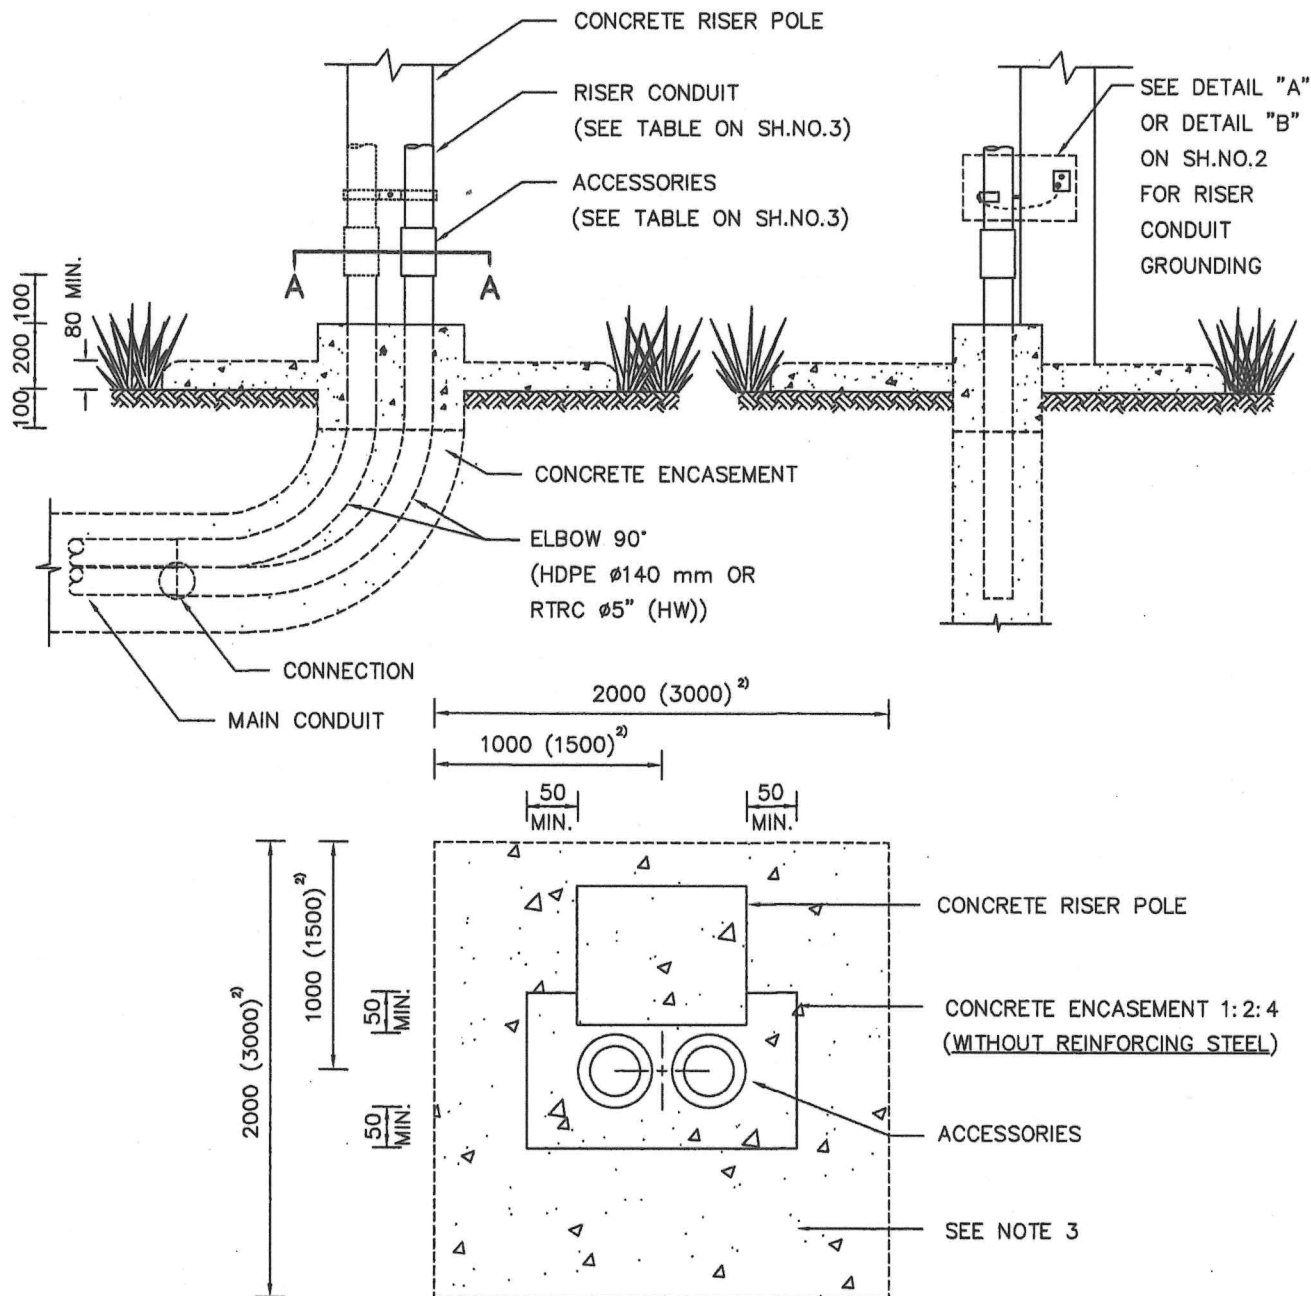


SECTION A-A

- NOTE**
1. DIMENSIONS ARE IN mm.
 2. THE VALUE IN BRACKET () IS FOR HDPE CONDUIT ONLY.
 3. FOR THE CONSTRUCTION OF 12/24 kV RISER IN THE AREA WHERE BOTTOM OF RISER POLE CAN BE OVERGROWN WITH GRASS OR WEEDS, RISER CONDUIT SHALL BE COVERED BY CONCRETE 2x2 m TO PREVENT FIRE DAMAGE.

1	REVISED DRAWING, TITLE, NUMBER OF SHEET & ADDED NOTE 2, 3			Month	13/4/63
REV.NO.	DESCRIPTION OF REVISIONS			BY	DATE
DR. Choochant	CHK. Sombant	METROPOLITAN ELECTRICITY AUTHORITY		SCALE	NONE
D'R.DIV.		PRIMARY RISER POLE WITH CONCRETE ENCASEMENT		SUPERSEDING	
DIR.DEPT.				SH.NO. 1 OF 3	
DEP.GOV.				DWG. NO. UG-7-103	
DATE	8/11/2533				

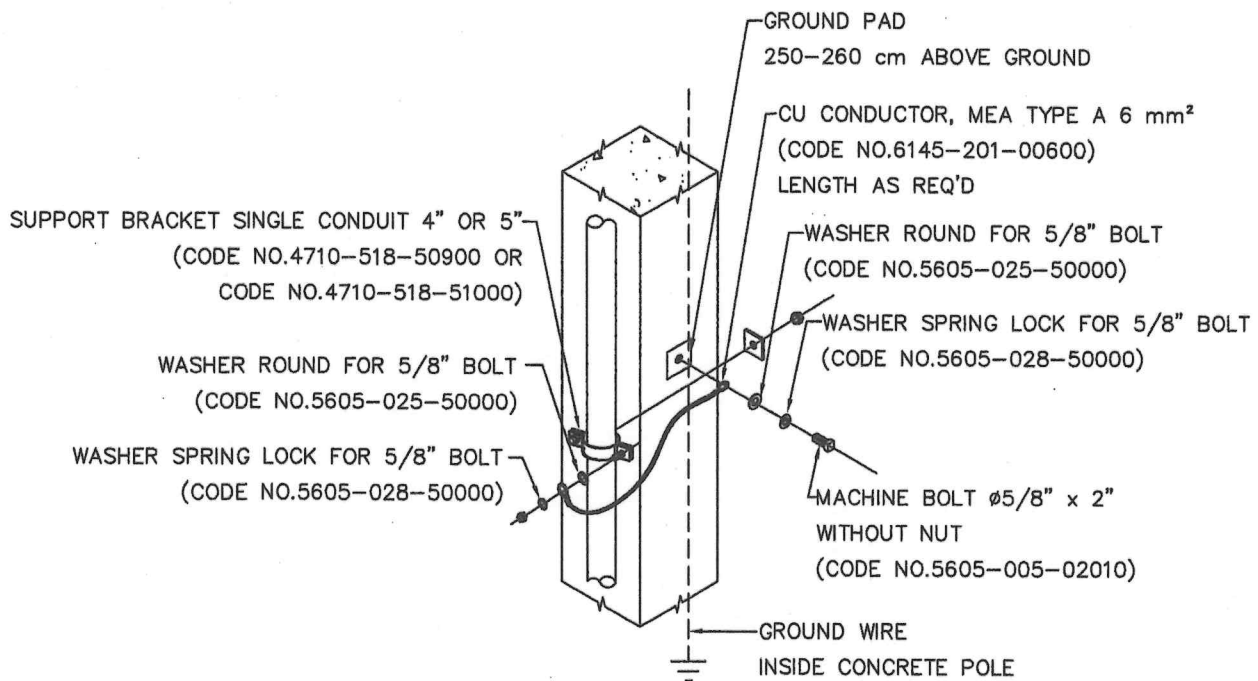

DETAIL "A"
(SINGLE CONDUIT)

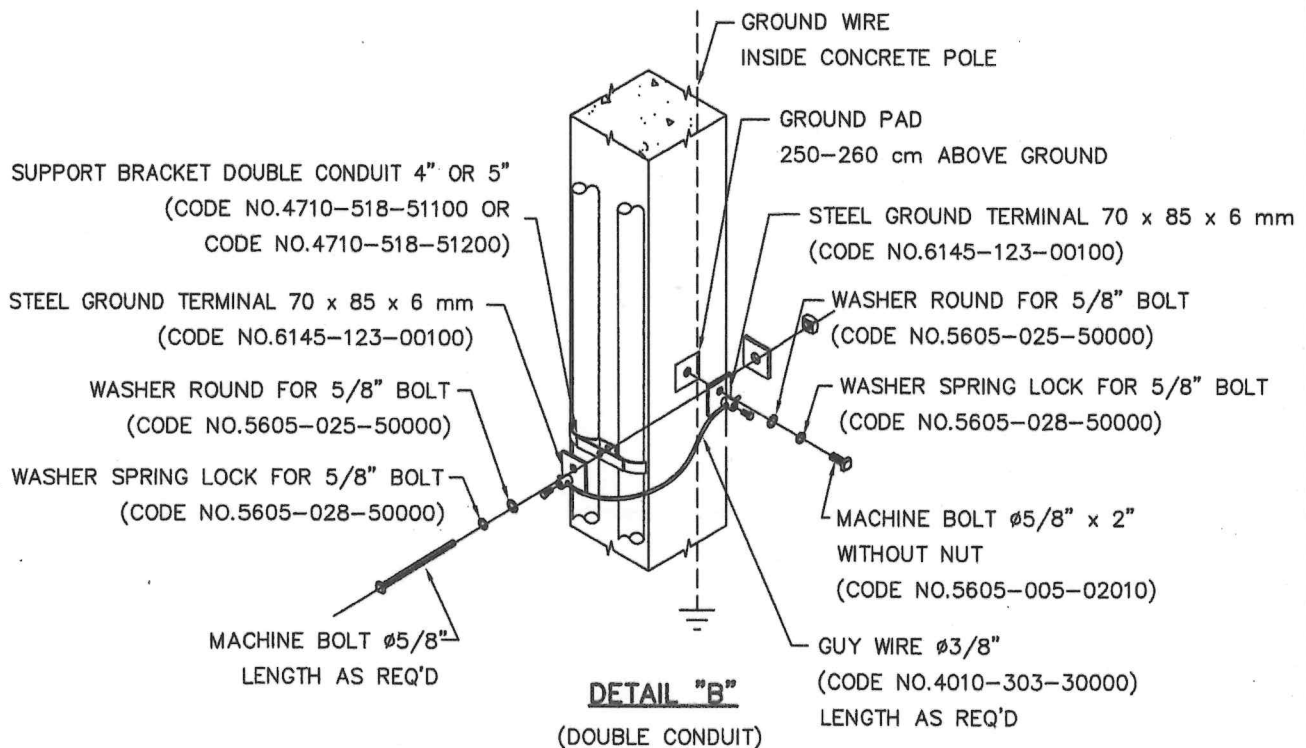

DETAIL "B"
(DOUBLE CONDUIT)

1	REVISED DRAWING, TITLE & NUMBER OF SHEET				Month	13/4/63
REV.NO.	DESCRIPTION OF REVISIONS				BY	DATE
DR. <i>Chaochari</i>	CHK. <i>Somant</i>	METROPOLITAN ELECTRICITY AUTHORITY			SCALE	NONE
D'R.DIV. <i>Vijaya</i>	PRIMARY RISER POLE WITH CONCRETE ENCASEMENT			SUPERSEDING		
DIR.DEPT. <i>Sae</i>				SH.NO. 2 OF 3		
DEP.GOV. <i>Thongra</i>				DWG. NO. UG-7-103		
DATE 8/11/2533						

Dr. Chaochari


TABLE SELECTION OF RISER CONDUIT AND ACCESSORIES.

CABLE SIZE (mm ²)	RISER CONDUIT	ACCESSORIES
70	RIGID STEEL CONDUIT (RSC) Ø4" (CODE NO.4710-518-40000)	REDUCING ADAPTER FOR HDPE CONDUIT Ø140 mm - RSC Ø4" (CODE NO.4730-563-41200)
240	RIGID STEEL CONDUIT (RSC) Ø5" (CODE NO.4710-518-50000)	HDPE COUPLING Ø140 mm - RSC Ø5" (CODE NO.4730-497-14000)
400	RIGID STEEL CONDUIT (RSC) Ø5" (CODE NO.4710-518-50000)	HDPE COUPLING Ø140 mm - RSC Ø5" (CODE NO.4730-563-42000)

NOTE SOMETIMES MAIN CONDUIT MAY BE LARGER FOR UG. CABLE 400 mm² INSTALLATION. THEREFORE BELOW 90' SHALL BE CHANGED TO Ø160 mm HPDE AND CONNECTED TO RSC Ø5" BY USING REDUCING ADAPTER FOR HDPE Ø160 mm - RSC Ø5" (CODE NO.4730-563-42000).


1	REVISED DRAWING, TITLE & NUMBER OF SHEET		Month	13/4/63
REV.NO.	DESCRIPTION OF REVISIONS		BY	DATE
DR. <i>Chaochari</i>	CHK. <i>Sombat</i>	METROPOLITAN ELECTRICITY AUTHORITY	SCALE	NONE
D/R.DIV. <i>Ugga</i>	PRIMARY RISER POLE WITH CONCRETE ENCASEMENT		SUPERSEDING	
DIR.DEPT. <i>Sae</i>			SH.NO. 3 OF 3	
DEP.GOV. <i>Thanya</i>			DWG. NO. UG-7-103	
DATE 8/11/2533				

2 *Chaochari* *Sh*

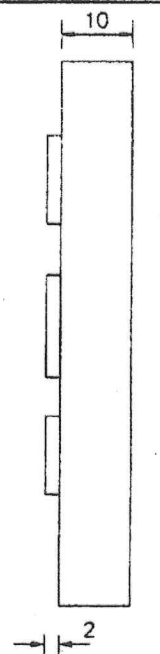

TOP VIEW

 SIDE VIEW



- NOTCH THE MARKER THROUGHOUT THE LENGTH AT THE SIZE OF.
3 mm. x 3 mm.

SECTION A-A

FRONT VIEW

TYPE A

CODE NO. 5620-636-40000

NOTES




1. DIMENSIONS ARE IN mm.
2. MATERIAL : MALLEABLE OR WROUGHT IRON, STEEL HOT-DIP GALVANIZED, MINIMUM AVERAGE OF ZINC-COATING SHALL NOT BE LESS THAN 120 MICRONS.

REV.NO.	DESCRIPTION OF REVISIONS				BY	DATE
DR. <i>Paramej</i>	CHK. <i>Witsha</i>	METROPOLITAN ELECTRICITY AUTHORITY			SCALE	1:1
DIR.DIV.		CABLE ROUTE MARKER FLUSH MOUTED TYPE (TYPE A)			SUPERSEDING	
DIR.DEPT.					SH.NO. 1 OF 2	
DEP.GOV.					DWG.	
DATE 5/7/2543					NO. 10A4-0445	

[Handwritten signature]

75

 75


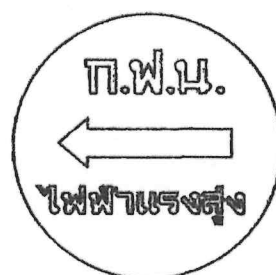
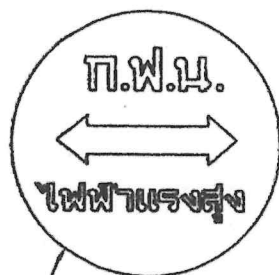
10
2

SEE DETAIL TYPE A

(CODE NO. 5620-636-40000) **TOP VIEW**

TYPE B

 (CODE NO. 5620-636-40100)

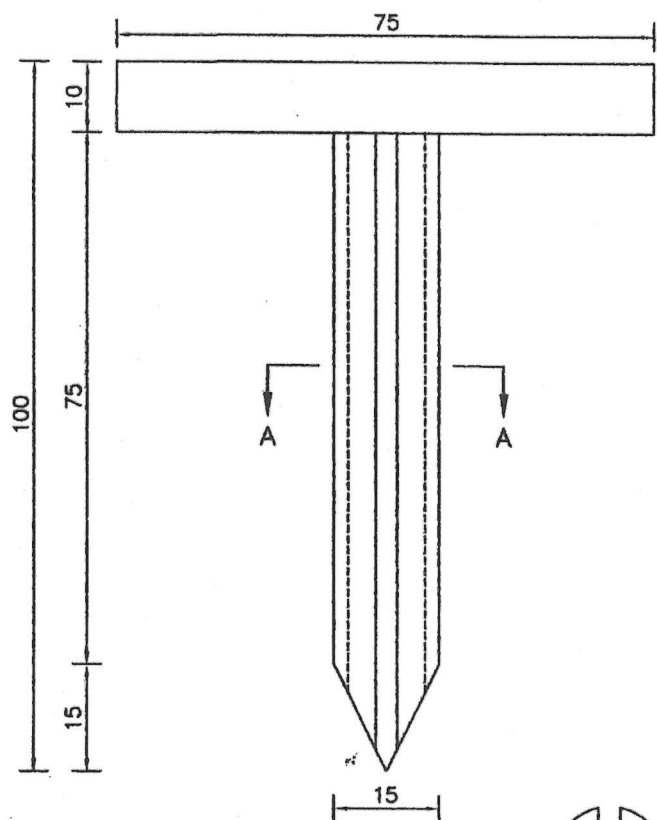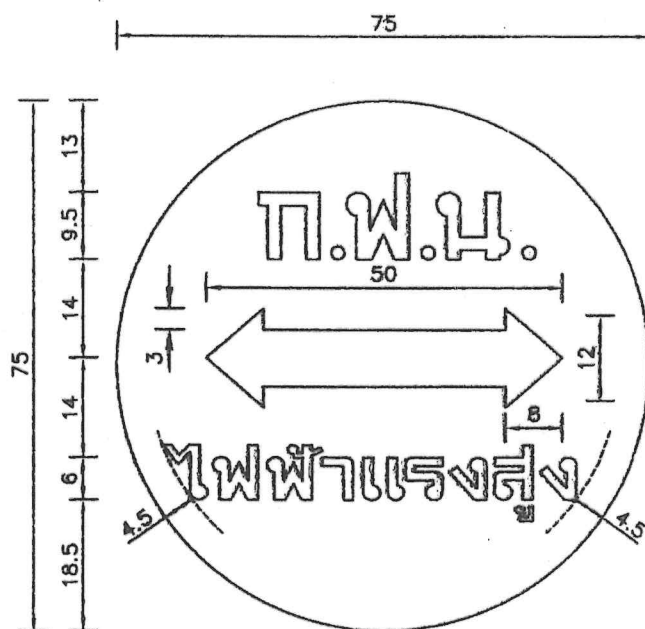
SIDE VIEW**FRONT VIEW****DETAIL** (SCALE 1:1)NOTCH THE MARKER THROUGHOUT THE LENGTH
AT THE SIZE OF 3 mm. x 3 mm.**SECTION A-A****NOTES**

1. DIMENSIONS ARE IN mm.
2. MATERIAL : GREY CAST IRON AS PER TIS. 536 OR EQUIVALENT.
3. PROTECTIVE COATING : ALL SURFACES SHALL BE COATED WITH COAL TAR EPOXY.
4. SEE MEA'S SPECIFICATION FOR FURTHER INFORMATION.

Handwritten signature

1	REVISED NOTE 2 & ADDED NOTE 3 & 4	Month	29/1/58
REV.NO.	DESCRIPTION OF REVISIONS	BY	DATE
DR. <i>Perang</i> CHK. <i>Wibha</i>	METROPOLITAN ELECTRICITY AUTHORITY	SCALE	1:1, NONE
DR.DIV. <i>Katanyan</i>	CABLE ROUTE MARKER	SUPERSEDING	
DR.DEPT. <i>Wijaya</i>	(FLUSH-MOUNTED TYPE)	SH.NO.	1 OF 5
DEP.GOV. <i>Jari</i>		DWG.	UG-8-012
DATE 15/3/2543		NO.	

Handwritten signature

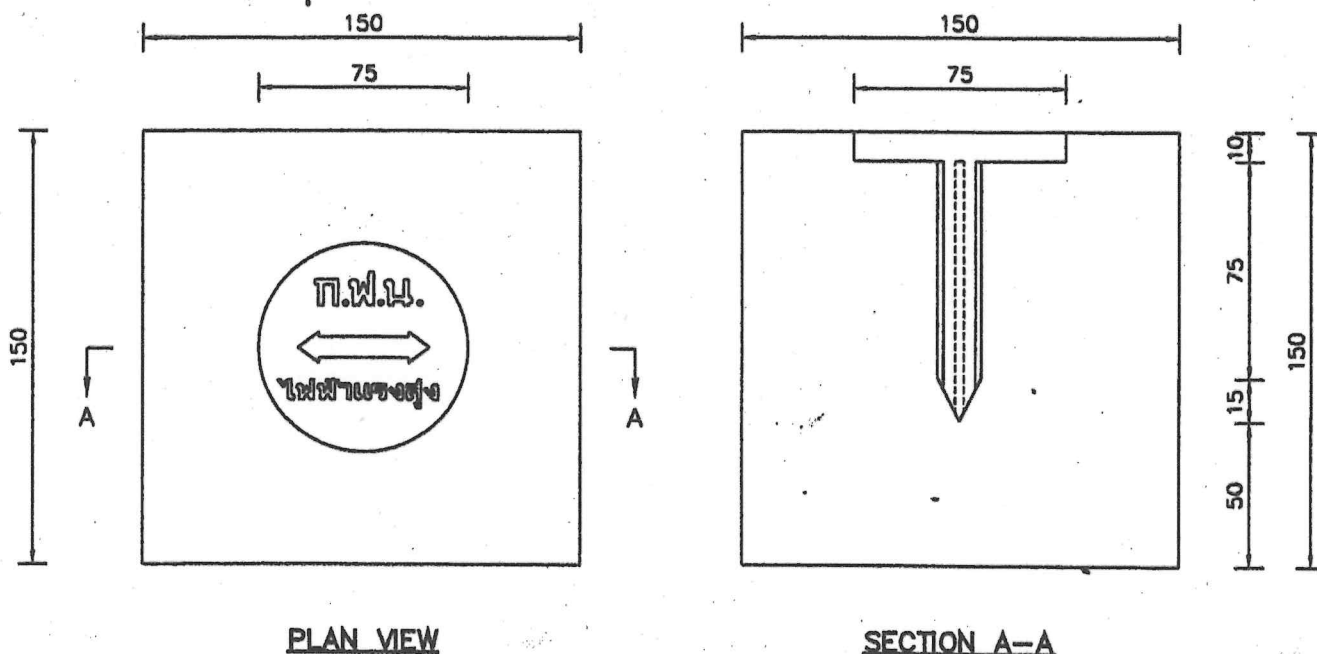

CONCRETE CUBE FOR SIDEWALK OR CRUSHED ROCK YARD AREA

INSTALLATION


1. CHECK THE UG. CABLE ROUTE AND MARK IT BEFORE REPAIRING THE SURFACE AREA.
2. CAST THE CONCRETE CUBE SIZE 150 x 150 x 150 mm. AND PRESS THE ROUTE MARKER ONTO IT.
3. EVERY 10 m. INTERVAL, FLUSH MOUNT THE CONCRETE CUBE WITH ROUTE MARKER ON THE CENTER LINE OF UG. CABLE ROUTE. THE SURFACE OF CUBE SHALL BE ADJUSTED TO THE SAME LEVEL AS REPAIRED SURFACE.
4. FINISH THE SURFACE AROUND THE CONCRETE CUBE SIMILAR TO THE NEARBY SURFACE.

FOR CONSTRUCTION REFERENCE ONLY

NOTES

1. DIMENSIONS ARE IN mm.
2. THE DRAWING SHOWN ABOVE IS TYPICAL INSTALLATION FOR TYPE A CABLE ROUTE MARKER.
3. IT CAN BE APPLIED IN SUBSTATION AREA BY PLACING THE CONCRETE CUBE FOR EVERY 5 m. (MAX.)

I	ADD NOTE 3	Pongsan 7/5/2543
REV.NO.	DESCRIPTION OF REVISIONS	BY DATE
DR. Pongmy	CHK. Alitsha	METROPOLITAN ELECTRICITY AUTHORITY
DIR.DIV. Ratamarjane		SCALE NONE
DIR.DEPT. Risa		SUPERSEDING
DEP.GOV. Juri		SH.NO. 2 OF 5
DATE 15/3/2543		DWG. NO. UG-9-012
	CABLE ROUTE MARKER (FLUSH-MOUNTED TYPE)	

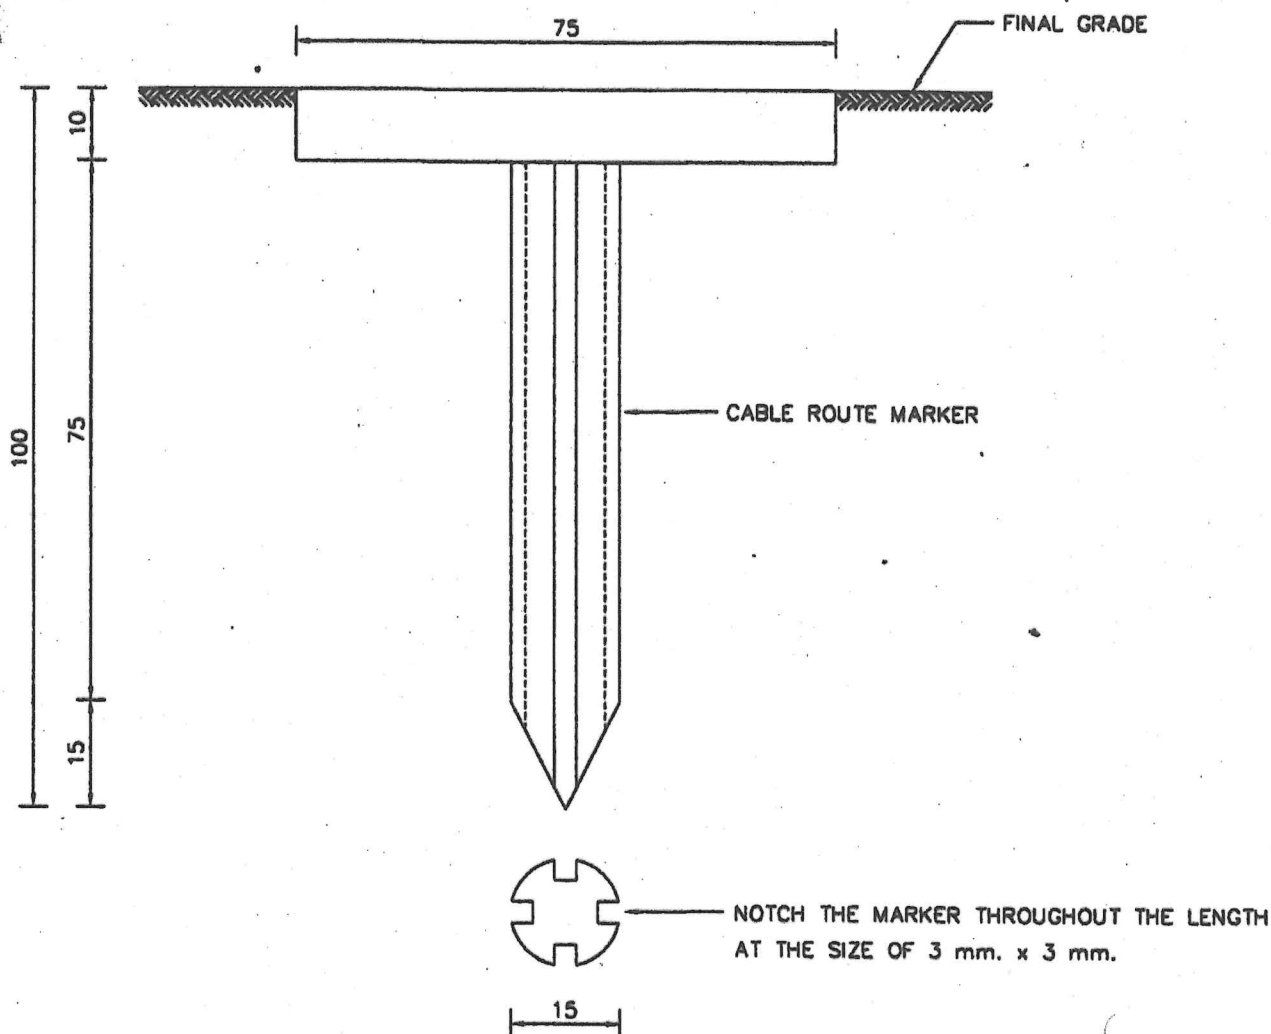

FOR UNFINISHED CONCRETE ROADWAY

INSTALLATION

1. CHECK THE UG. CABLE ROUTE AND MARK IT BEFORE REPAIRING THE ROAD SURFACE.
2. FILL CONCRETE TO REPAIR THE ROAD SURFACE AND SWEEP IT TO THE SAME LEVEL AS THE NEARBY SURFACE.
3. EVERY 10 m. INTERVAL, WHEN THE CONCRETE NEARLY TAKES THE INITIAL SET, WEDGE THE ROUTE MARKER IN THE CENTER LINE OF UG. CABLE ROUTE UNTIL THE HEAD IS FLUSH TO THE ROAD SURFACE.
4. FINISH THE SURFACE AROUND THE ROUTE MARKER SIMILAR TO THE NEARBY SURFACE.


NOTES.

1. DIMENSIONS ARE IN mm.
2. IT CAN BE APPLIED IN SUBSTATION AREA BY PLACING THE ROUTE MARKER FOR EVERY 5 m. (MAX.)

FOR CONSTRUCTION REFERENCE ONLY

I	ADD NOTE 2				Pongsan	7/5/2545
REV.NO.	DESCRIPTION OF REVISIONS				BY	DATE
DR. <i>Peram</i>	CHK. <i>Nitcha</i>	METROPOLITAN ELECTRICITY AUTHORITY			SCALE	1:1
DIR.DIV. <i>Ratnawajana</i>		CABLE ROUTE MARKER (FLUSH-MOUNTED TYPE)			SUPERSEDING	
DIR.DEPT. <i>Yoon</i>					SH.NO. 3 OF 5	
DEP.GOV. <i>Jari</i>					DWG. UG-9-012	
DATE 15/3/2543					NO.	

Signature

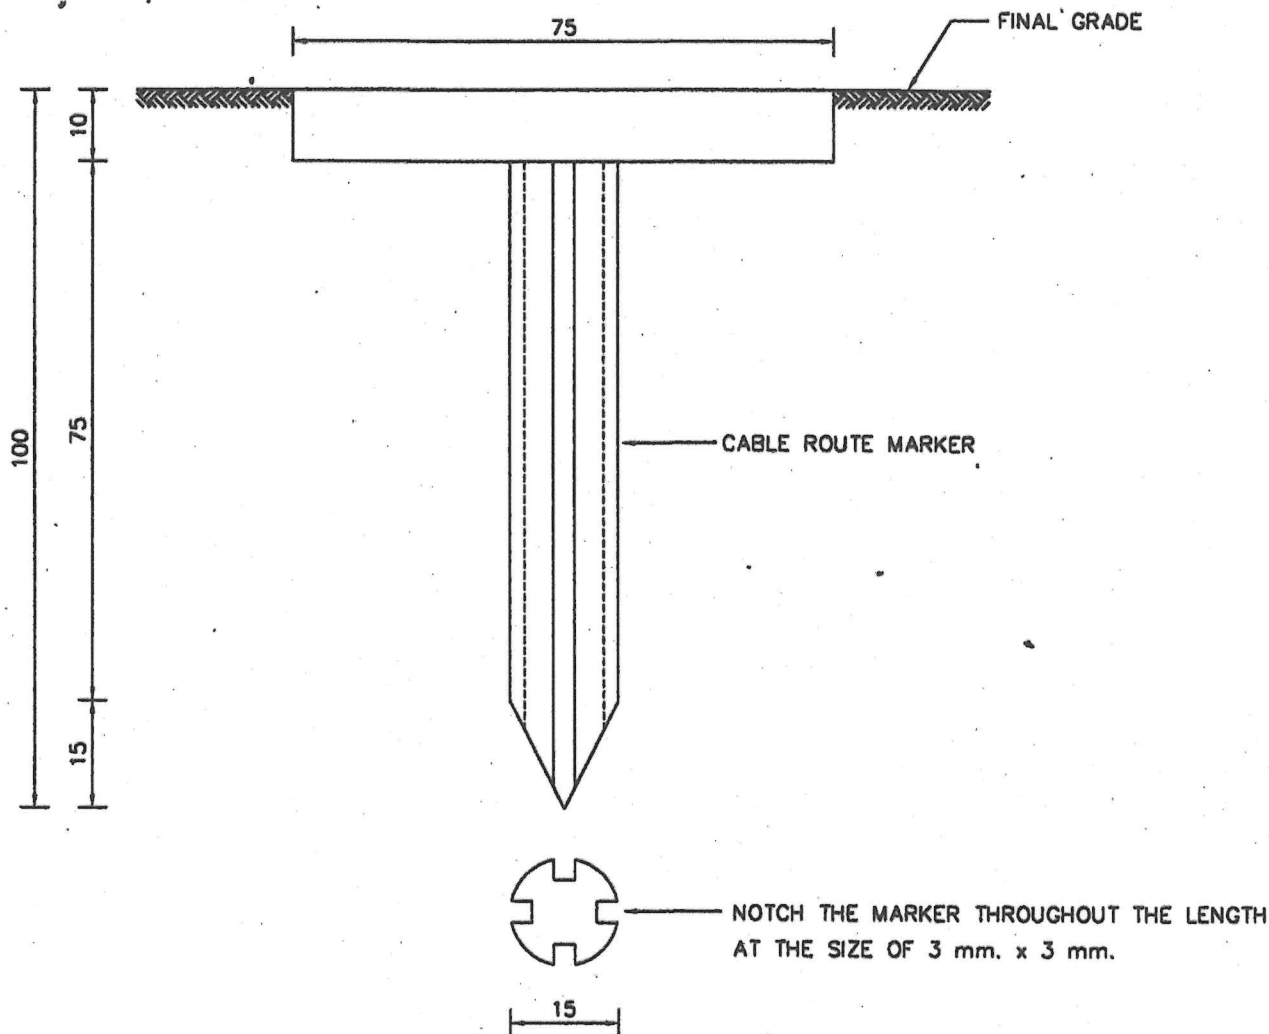

FOR UNFINISHED ASPHALT ROADWAY

INSTALLATION


1. CHECK THE UG. CABLE ROUTE AND MARK IT BEFORE REPAIRING THE ROAD SURFACE.
2. COVER THE ROAD SURFACE WITH ASPHALT.
3. MAKE THE FIRST PRESSING ON ASPHALT SURFACE.
4. EVERY 10 m. INTERVAL, WEDGE THE ROUTE MARKER IN THE CENTER LINE OF UG. CABLE ROUTE UNTIL THE HEAD IS FLUSH TO THE ROAD SURFACE.
5. PRESS THE ASPHALT SURFACE WITH ROUTE MARKER AGAIN.

NOTES

1. DIMENSIONS ARE IN mm.
2. IT CAN BE APPLIED IN SUBSTATION AREA BY PLACING THE ROUTE MARKER FOR EVERY 5 m. (MAX.)

FOR CONSTRUCTION REFERENCE ONLY

1	ADD NOTE 2	Pongsan	7/5/45
REV.NO.	DESCRIPTION OF REVISIONS	BY	DATE
DR. <i>Ponam</i>	CHK. <i>Witche</i>	METROPOLITAN ELECTRICITY AUTHORITY	
DIR.DIV. <i>Ratan arjuna</i>	CABLE ROUTE MARKER (FLUSH-MOUNTED TYPE)		SCALE 1:1
DIR.DEPT. <i>Uga</i>			SUPERSEDING
DEP.GOV. <i>Jari</i>			SH.NO. 4 OF 5
DATE 15/3/2543			DWG. NO. UG-9-012

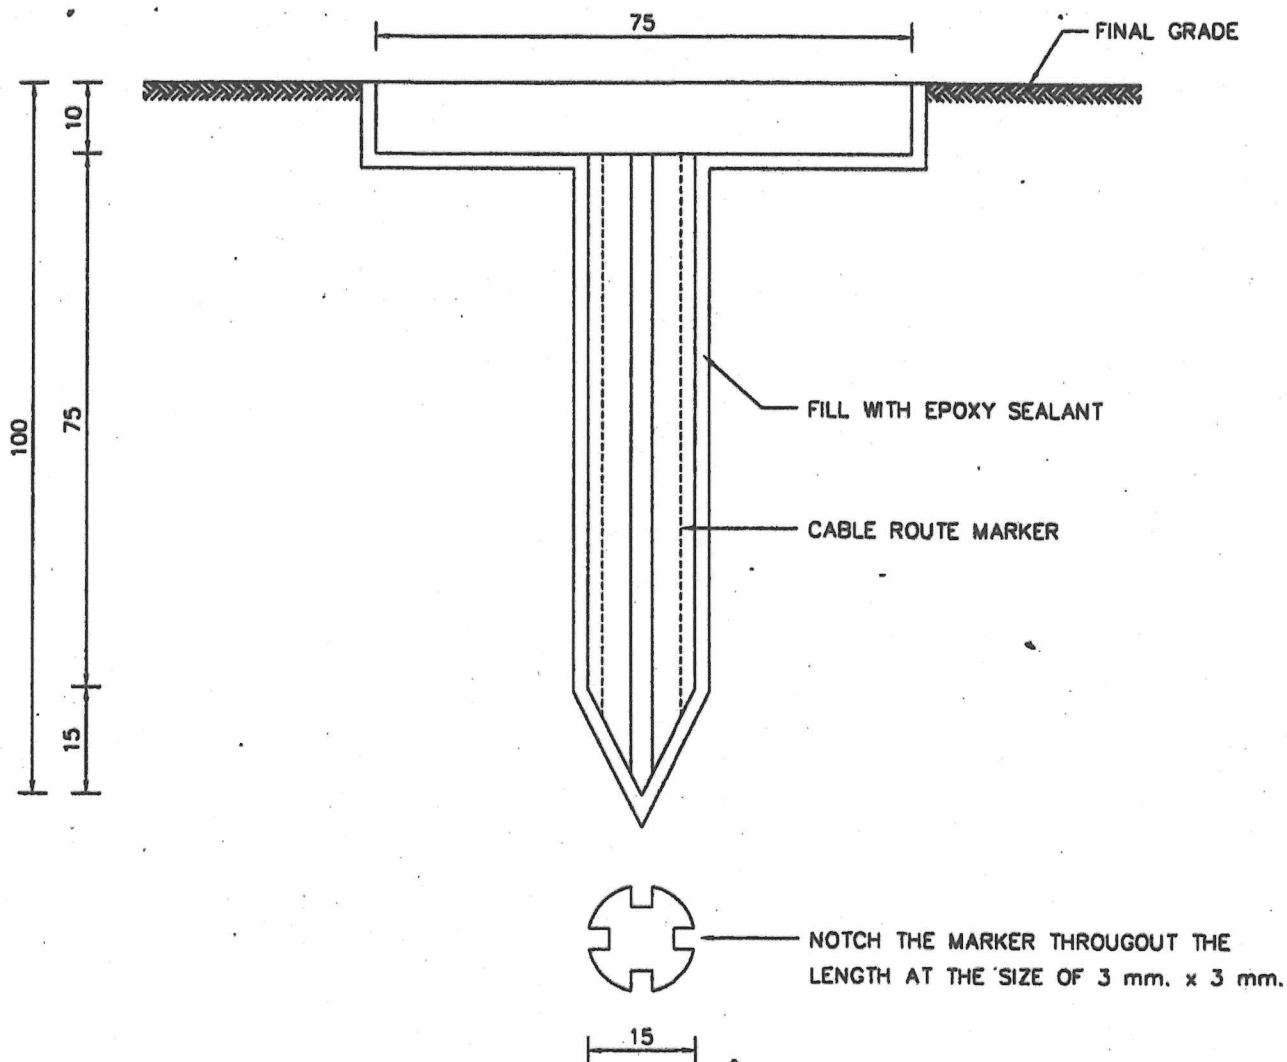

FOR FINISHED CONCRETE OR ASPHALT ROADWAY

INSTALLATION

1. CHECK THE UG. CABLE ROUTE AND MARK IT.
2. EVERY 10 m. INTERVAL, DRILL $\phi 25$ mm. AND 100 mm. DEEP HOLE ON THE ROAD SURFACE IN THE CENTER LINE OF UG. CABLE ROUTE.
3. ENLARGE THE HOLE AT THE ROAD SURFACE TO BE $\phi 85$ mm. AND 10 mm. IN DEPTH.
4. PUT THE ROUTE MARKER INTO THE HOLE UNTIL THE HEAD IS FLUSH TO THE ROAD SURFACE.
5. FILL THE EPOXY INTO THE HOLE.
6. FINISH THE SURFACE AROUND THE ROUTE MARKER SIMILAR TO THE NEARBY SURFACE.

NOTES

1. DIMENSIONS ARE IN mm.

2. IT CAN BE APPLIED IN SUBSTATION AREA BY PLACING THE ROUTE MARKER FOR EVERY 5 m. (MAX.)

FOR CONSTRUCTION REFERENCE ONLY

1	ADD NOTE 2			Pongsan	7/5/45
REV.NO.	DESCRIPTION OF REVISIONS			BY	DATE
DR. <i>Ponang</i>	CHK. <i>Attha</i>	METROPOLITAN ELECTRICITY AUTHORITY		SCALE	1:1
DIR.DIV. <i>Ratana</i>	<i>rojana</i>	CABLE ROUTE MARKER (FLUSH-MOUNTED TYPE)		SUPERSEDING	
DIR.DEPT. <i>Yani</i>				SH.NO. 5	OF 5
DEP.GOV. <i>Yani</i>				DWG. NO.	UG-9-012
DATE	15/3/2543				

Pongsan
M

CASE 1 FOR UNFINISHED OR FINISHED CONCRETE/ASPHALT SURFACE PAVEMENT

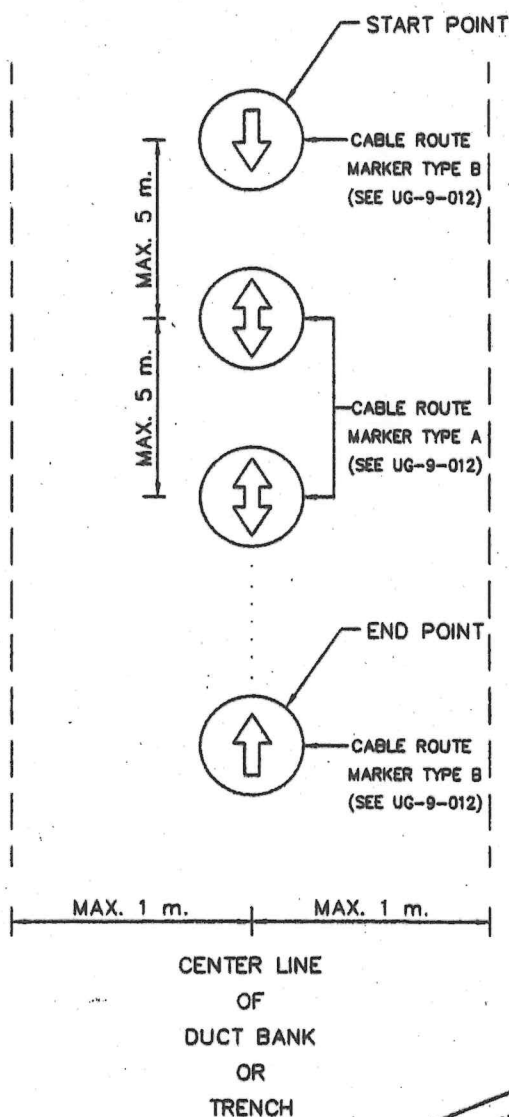


FIG. A

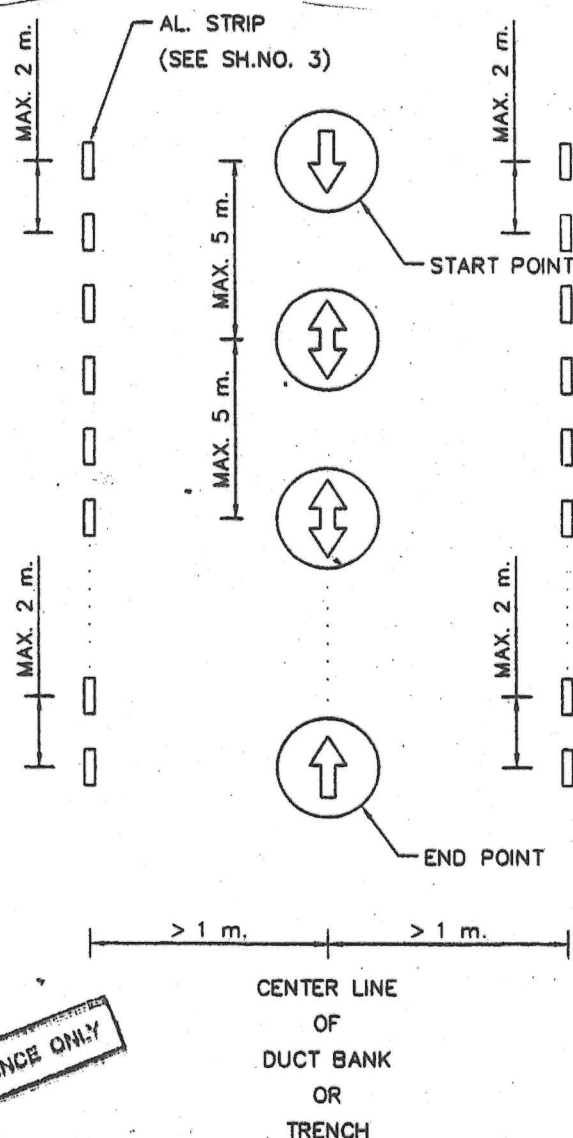


FIG. B

FOR CONSTRUCTION REFERENCE ONLY

NOTES.

- REGULATION** : DO NOT TAKE FOLLOWING OPERATIONS : DIGGING, DRILLING, CARVING, PUNCHING ETC. IN THE BOUNDARY WHICH IS INDICATED BY CABLE ROUTE MARKER WITHOUT PRIOR WRITTEN PERMISSION OF AUTHORIZED PERSON.
- APPLICATION** - USE FIG.A WHERE DUCT BANK/TRENCH WIDTH NOT MORE THAN 2 m.
- USE FIG.B WHERE DUCT BANK/TRENCH WIDTH MORE THAN 2 m.

REV.NO.	DESCRIPTION OF REVISIONS			BY	DATE
DR. <i>Maschai</i>	CHK. <i>Pongsan</i>	METROPOLITAN ELECTRICITY AUTHORITY			SCALE NONE
DIR.DIV. <i>R. Thani</i>	RECOMMENDED PRACTICE FOR INDICATING UNDERGROUND CABLE ROUTE IN SUBSTATION			SUPERSEDING	
DIR.DEPT. <i>A. maeawad</i>				SH.NO. 1 OF 3	
DEP.GOV. <i>W</i>				DWG. NO. UG-9-013	
DATE 13/5/2545					

2
Jim Hwa
M

CASE 2 FOR CRUCHED - ROCK AREA (YARD)

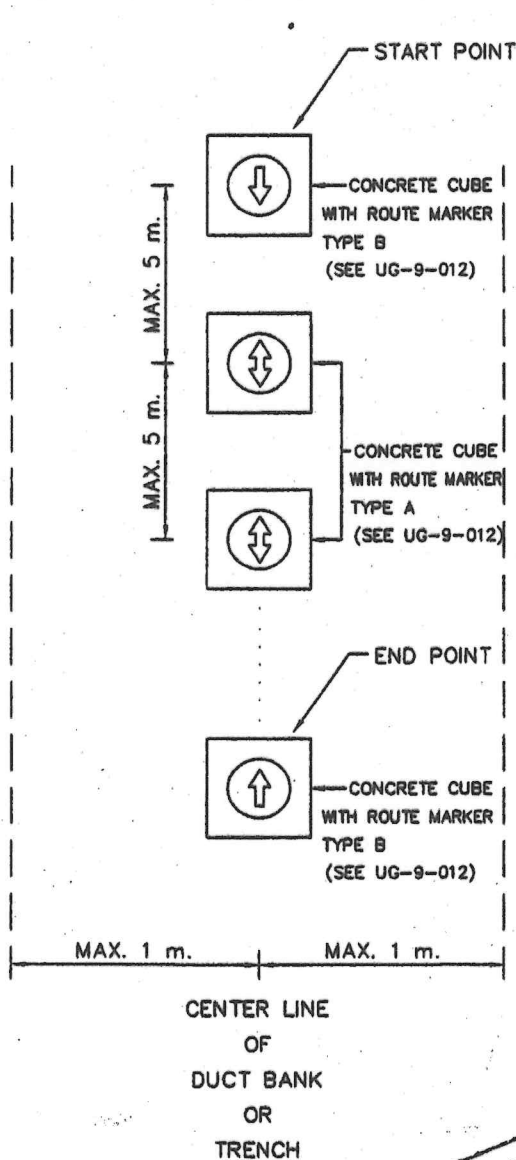


FIG. A

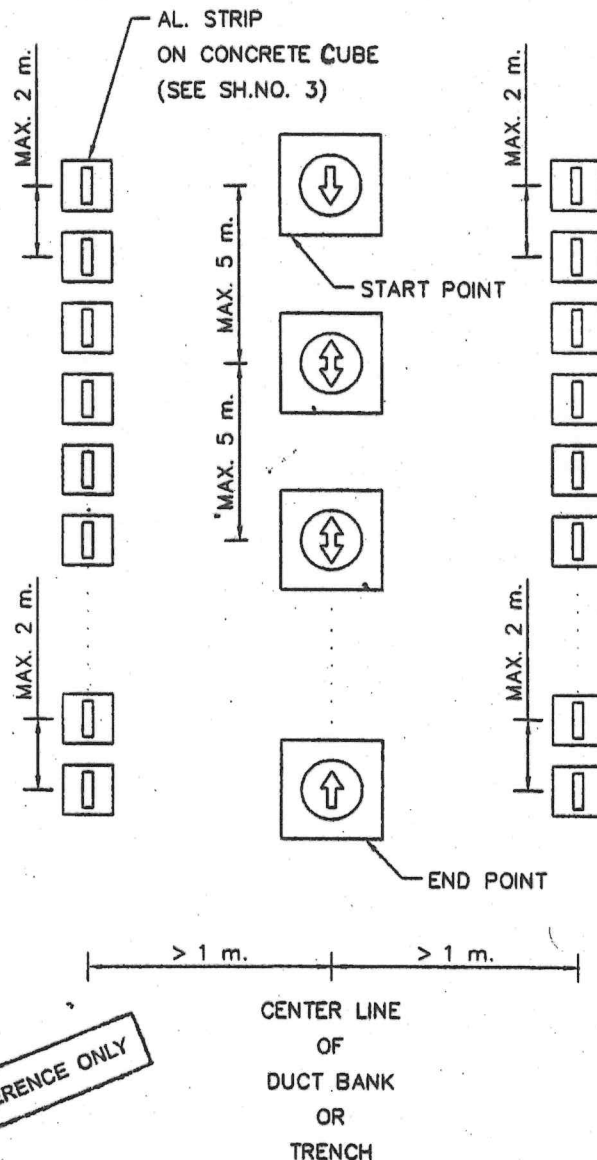


FIG. B

FOR CONSTRUCTION REFERENCE ONLY

NOTES

- REGULATION** : DO NOT TAKE FOLLOWING OPERATIONS : DIGGING, DRILLING, CARVING, PUNCHING ETC. IN THE BOUNDARY WHICH IS INDICATED BY CABLE ROUTE MARKER WITHOUT PRIOR WRITTEN PERMISSION OF AUTHORIZED PERSON.
- APPLICATION** - USE FIG.A WHERE DUCT BANK/TRENCH WIDTH NOT MORE THAN 2 m.
- USE FIG.B WHERE DUCT BANK/TRENCH WIDTH MORE THAN 2 m.

REV.NO.	DESCRIPTION	OF REVISIONS	BY	DATE
DR. <i>Marchai</i>	CHK. <i>Pongsan</i>	METROPOLITAN ELECTRICITY AUTHORITY		SCALE NONE
DIR.DIV. <i>R. Thani</i>	RECOMMENDED PRACTICE FOR INDICATING UNDERGROUND CABLE ROUTE IN SUBSTATION		SUPERSEDING	
DIR.DEPT. <i>As moanoo</i>			SH.NO. 2 OF 3	
DEP.GOV. <i>gpe</i>			DWG. UG-9-013	
DATE 13/5/2545			NO.	

2
Chom Boon
M